




1 KITCHEN PLAN
SCALE: 1/2" = 1'-0"

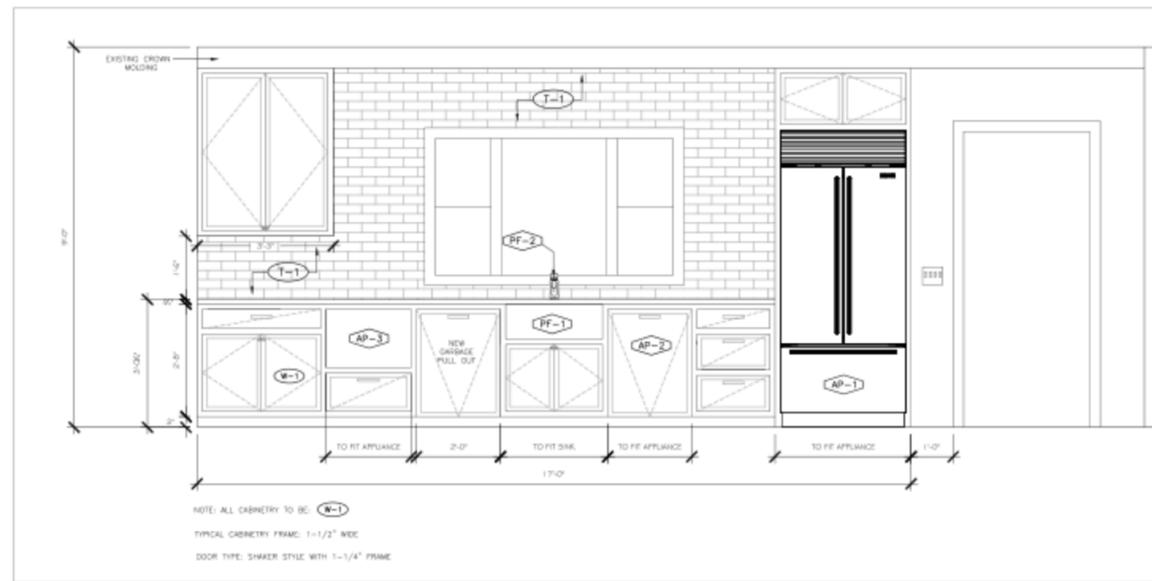


2 ELEVATION A
SCALE: 1/2" = 1'-0"

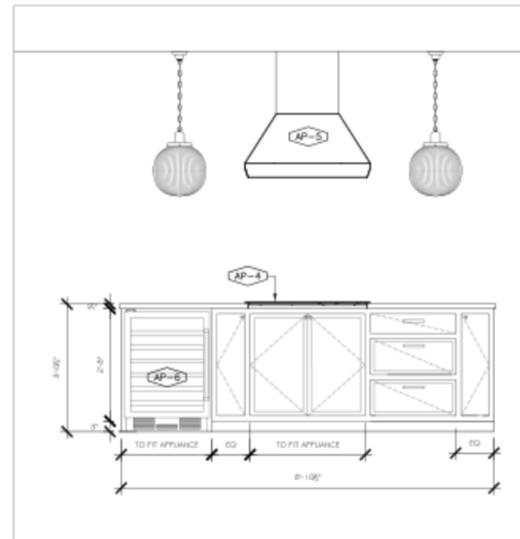

3 ELEVATION B
SCALE: 1/2" = 1'-0"

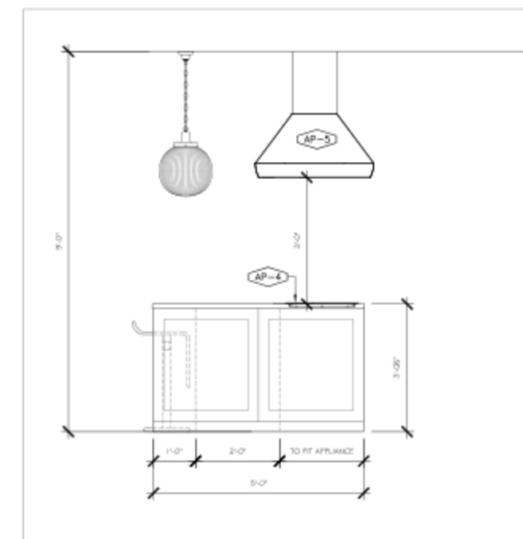

4 ELEVATION C
SCALE: 1/2" = 1'-0"

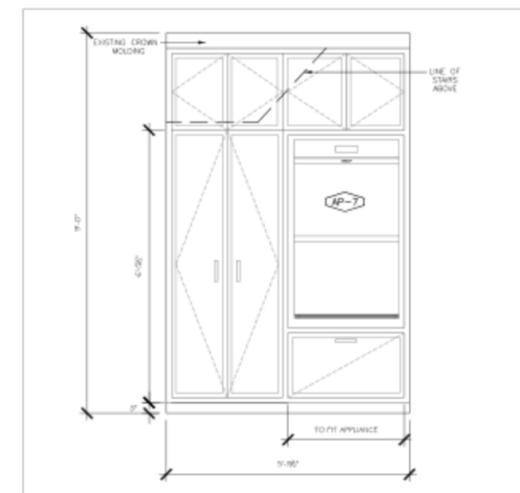

5 ELEVATION D
SCALE: 1/2" = 1'-0"

LEGEND - PLUMBING FIXTURES	
Symbols	Specifications
AP-1	NEW 36" WIDE REFRIGERATOR/FREEZER SUGGESTION: SUBZERO BI-36JFD/S OR SIMILAR
AP-2	DISHWASHER - REUSE EXISTING PANEL READY - NEW PANEL TO MATCH CABINETRY
AP-3	MICROWAVE DRAWER - REUSE EXISTING
AP-4	NEW 36" WIDE COOKTOP SUGGESTION: WOLF CI36ST/S INDUCTION OR SIMILAR **ALTERNATE: GAS COOKTOP WOLF CG36SP/S OR SIMILAR
AP-5	NEW ISLAND HOOD SUGGESTION: WOLF FI363A18 ISLAND HOOD WITH 18" SLEEVE DUCT **ALTERNATE: WOLF DD36 36" WIDE DOWNDRAFT VENTILATION
AP-6	NEW 24" WINE FRIDGE SUGGESTION: SUBZERO UW-24/S OR SIMILAR
PF-1	SINK - REUSE EXISTING
PF-2	FAUCET - REUSING EXISTING

LEGEND - MATERIALS	
Symbols	Specifications
MATERIAL - STONE	
S-1	STONE: CARRARA MARBLE: 1-1/4" THICK **ALTERNATE: CAESAR STONE: 1-1/4" THICK
T-2	BACKSPASH TILE: TBD SUBWAY TILE OR SIMILAR
W-1	PAINTED WOOD: SHAKER STYLE DOOR - INSET TO SURROUNDING FRAME COLOR: TBD DEPENDING ON MANUFACTURERS

NOTES

- ALL WORK SHOWN ON THIS DRAWING SHALL BE PERFORMED BY THE GENERAL CONTRACTOR UNLESS SPECIFICALLY INDICATED TO BE "BY OTHERS".
- ALL PLANS, SPECIFICATIONS AND SHOWN DESIGNS ARE THE PROPERTY OF WINTER MCDERMOTT DESIGN.
- CONTRACTORS ARE RESPONSIBLE FOR CHECKING ALL FIELD DIMENSIONS AND CONDITIONS AT THE JOB SITE. ANY DISCREPANCIES BETWEEN ACTUAL FIELD CONDITIONS AND WINTER MCDERMOTT DESIGN DOCUMENTS MUST BE CLARIFIED BEFORE COMMENCEMENT OF WORK.
- SHOP DRAWINGS TO BE SUBMITTED TO WINTER MCDERMOTT DESIGN FOR APPROVAL BEFORE ANY MILLWORK COMMENCES
- ALL FINISH SAMPLES TO BE SUBMITTED TO WINTER MCDERMOTT DESIGN FOR APPROVAL.
- GENERAL CONTRACTOR SHALL VISIT THE SITE AND SHALL NOTE ALL EXISTING CONDITIONS INVOLVING EXTENT OF THE WORK INDICATED ON THE DRAWING AND SHALL BE PRICED ACCORDINGLY.
- REFER TO HARDWARE CUT SHEETS FOR DIMENSIONS OF HARDWARE
- REFER TO SPECIFICATIONS FOR PLUMBING AND APPLIANCES.
- REFER TO ARCHITECTURAL PLANS FOR OVERALL DIMENSIONS

No. ISSUED DATE

ISSUED FOR BID 1/30/17

WINTER MCDERMOTT DESIGN
197 MADISON STREET
SAG HARBOR NY 11963
T 631.488.0988

GLEN AND NATALIA EDELSON
142 COOPERS FARM
SOUTHAMPTON, NY

KITCHEN - BID DRAWING

SCALE:	PROJECT MANAGER:	FLOOR NO.:
AS NOTED	MWM	-
JOB NO: 2129	DRAWN BY: MWM	-
FILE NAME: -	DESIGNED BY: -	DRAWING NO: -
DATE: 12/5/17	CHECKED BY: -	I-1