



MARKZEFF

# LITTLE SAINT JAMES

No. 6A RED HOOK QUARTER  
CST. THOMAS, U.S. VIRGIN ISLAND

KITCHEN (REVISION 1): 10. 11. 2010

## DRAWING INDEX

ID0.00	COVER SHEET
ID0.04	SCHEDULES AND NOTES
ID5.01A	ENLARGED KITCHEN FLOOR PLAN
ID5.01B	ENLARGED KITCHEN ELECTRICAL PLAN
ID5.01C	ENLARGED KITCHEN LIGHTING PLAN
ID5.01D	ENLARGE KITCHEN FINISHES PLAN
ID5.01E	ENLARGED FURNITURE PLAN
ID6.01A	KITCHEN INTERIOR ELEVATIONS & DETAILS
ID6.01B	KITCHEN INTERIOR ELEVATIONS & DETAILS
ID7.01A	MILLWORK DETAILS: KITCHEN ISLAND
ID7.01B	MILLWORK DETAILS: KITCHEN CABINETS
ID7.01C	MILLWORK DETAILS: KITCHEN CABINETS
ID7.01D	MILLWORK DETAILS: KITCHEN CABINETS
ID7.01E	MILLWORK DETAILS: KITCHEN BANQUETTE
ID7.01F	MILLWORK DETAILS: KITCHEN BANQUETTE

## LAND SURVEYORS

**BRIAN MOSLEY &  
ASSOCIATES, INC**  
4003 RAAPHUNE HILL ROAD  
SUITE 606, ST. THOMAS, VI 00802  
PHONE (340) 774-5310  
FAX (340) 776-4090  
CONTACT: RYAN WISEHART

## CONTRACTOR

**LSJ, LLC**  
AMERICAN YACHT HARBOR  
6100 RED HOOK QUARTER, SUITE B3  
ST. THOMAS, VI 00802  
PHONE (340) 779-8054  
FAX (340) 779-8055  
CONTACT: GARY KERNEY

## DESIGNER

**MARKZEFF**  
515 WEST 20TH STREET, 4W  
NEW YORK, NY 10011  
PHONE: 212.624.4004  
FAX: 212.624.4006  
CONTACT: JORGE PORTA

ARCHITECTURAL FINISHES SCHEDULE (REFER SHEET ID5.01D FOR LOCATIONS)

ITEM TYPE	ITEM No.	DESCRIPTION	MANUFACTURER	COLOR / FINISH	THICKNESS	MODEL No.	GROUT COLOR	COMMENTS
FLOOR TILE	F-01	24 X 24 STONE FLOORING	CHESTERSTONE	PURE WHITE POLISHED	3/4 THK	#141	STANDARD WHITE	BY GENERAL CONTRACTOR
PAINT	PT-01	WALL AND CEILING PAINT	BENJAMIN MOORE	SUPER WHITE FLAT	NA	777	NA	BY GENERAL CONTRACTOR
PAINT	PT-02	DOOR & TRIM PAINT	BENJAMIN MOORE	SUPER WHITE SEMI GLOSS	NA	777	NA	BY GENERAL CONTRACTOR
STONE	ST-02	COUNTERTOP & BACKSPLASH	CHESTERSTONE	EGGSHELL POLISHED	1 1/4 THK, SQUARE EDGE	#341	NA	BY MILLWOMEN (PROVIDE SAMPLES FOR APPROVAL)
MISCELLANEOUS FINISHES SCHEDULE	SP-01	CABINET EXTENSION	BENJAMIN MOORE	CHARMILLY LAKE	NA	#21170	NA	BY MILLWOMEN (PROVIDE SAMPLES FOR APPROVAL)
MISCELLANEOUS FINISHES SCHEDULE	NA	CABINET INTERIOR	NA	STANDARD WHITE (MATT)	NA	NA	NA	BY MILLWOMEN (PROVIDE SAMPLES FOR APPROVAL)

LIGHT FIXTURES (REFER SHEET ID5.01C FOR LOCATIONS)

ITEM TYPE	ITEM No.	DESCRIPTION	MANUFACTURER	COLOR / FINISH	THICKNESS	MODEL No.	GROUT COLOR	COMMENTS
DECORATIVE PENDANT LIGHT FIXTURE	LT-01	SPHERES PRISM SINGLE PENDANT	RESTORATION HARDWARE	ALUMINUM	NA	#807001	NA	SUPPLIED BY OWNER
UNDERCABINET TRACK LIGHT FIXTURE	LT-02	UNDIMMED RECESSED PL-INLIGHT	LICHTER LIGHTING	WHITE / MATT	NA	LPK-12-0-W	NA	BY MILLWOMEN
CEILING FAN	LT-03	CEILING FAN	TBD	WHITE	TBD	TBD	NA	SUPPLIED BY OWNER
DECORATIVE OUTDOOR SCIENCE	LT-04	SCIENCE	NA	NA	NA	NA	NA	BY GENERAL CONTRACTOR (DO NOT MATCH EXISTING AND TO BE APPROVED BY OWNER)

PLUMBING / TOILET ACCESSORIES SCHEDULE (REFER SHEET ID5.01A FOR LOCATION)

ITEM TYPE	ITEM No.	DESCRIPTION	MANUFACTURER	COLOR / FINISH	MODEL No.	COMMENTS
DOUBLE BASIN SINK	P-01	SINK	FRANKE S&S	STAINLESS STEEL	AR1203	SUPPLIED BY OWNER (OWNER TO PROVIDE MILLWOMEN WITH TEMPLATES UPON REQUEST)
SINGLE BASIN SINK	P-02	SINK	FRANKE S&S	STAINLESS STEEL	FSK 1100N216	SUPPLIED BY OWNER (OWNER TO PROVIDE MILLWOMEN WITH TEMPLATES UPON REQUEST)
FAUCET	P-03A	PULL-OUT FAUCET	GRONE	STAINLESS STEEL	33799 S00	SUPPLIED BY OWNER (OWNER TO PROVIDE MILLWOMEN WITH TEMPLATES UPON REQUEST)
POT FILLER FAUCET	P-03	WALL MOUNTED POT FILLER	GRONE	STAINLESS STEEL	3141 S00	SUPPLIED BY OWNER TO GENERAL CONTRACTOR

APPLIANCE / EQUIPMENT SCHEDULE (REFER SHEET ID5.01B FOR LOCATION)

ITEM TYPE	ITEM No.	DESCRIPTION	MANUFACTURER	COLOR / FINISH	MODEL No.	COMMENTS
DISHWASHER	NA	24 INCH DISHWASHER	KITCHEN AID	STAINLESS STEEL	KJDC0F15S	SUPPLIED BY OWNER (OWNER TO PROVIDE FINAL APPROVAL)
STONE	NA	REUSE EXISTING W/ STOVE	NA	STAINLESS STEEL	NA	SUPPLIED BY OWNER (REUSE EXISTING)
EXHAUST HOOD	NA	REUSE EXISTING W/ WIDE EXHAUST HOOD	NA	STAINLESS STEEL	NA	SUPPLIED BY OWNER (REUSE EXISTING)
3/8" REFRIGERATOR	NA	BUILT-IN SINGLE DOOR REFRIGERATOR	SUB-ZERO	STAINLESS STEEL / TUBULAR HINGLES / HINGES ON RIGHT SIDE	BLSJ315TH	SUPPLIED BY OWNER (OWNER TO PROVIDE FINAL APPROVAL)
3/8" REFRIGERATOR	NA	BUILT-IN OVER & UNDER REFRIGERATOR	SUB-ZERO	STAINLESS STEEL / TUBULAR HINGLES / HINGES ON LEFT SIDE	BLSJ315TH	SUPPLIED BY OWNER (OWNER TO PROVIDE FINAL APPROVAL)
TELEPHONE	NA	NA	NA	NA	NA	SUPPLIED BY OWNER (OWNER TO PROVIDE FINAL APPROVAL)
-COMBINATION OVEN-MICROWAVE	NA	NA	NA	NA	NA	SUPPLIED BY OWNER (OWNER TO PROVIDE FINAL APPROVAL)
DOUBLE OVEN (W/ MICROVAE COMBI)	NA	3/8" MICRO COMBO SELF-CLEAN WALL OVEN	MAYTAG	STAINLESS STEEL	MHW7330WS	SUPPLIED BY OWNER (OWNER TO PROVIDE FINAL APPROVAL)
COFFEE MAKER	NA	TBD	TBD	TBD	TBD	SUPPLIED BY OWNER (OWNER TO PROVIDE FINAL APPROVAL)
FLAT SCREEN TV	NA	TBD	TBD	TBD	TBD	SUPPLIED BY OWNER (OWNER TO PROVIDE FINAL APPROVAL)
ICE MAKER	NA	1/2 INCH ICEMAKER	KITCHEN AID	STAINLESS STEEL	KJCI00WNS	SUPPLIED BY OWNER (OWNER TO PROVIDE FINAL APPROVAL)
WASHER/DRYER (SEPARATE DISPOSAL)	NA	TBD	TBD	TBD	TBD	SUPPLIED BY OWNER (OWNER TO PROVIDE FINAL APPROVAL)
AUDIO VISUAL EQUIPMENT	NA	TBD	TBD	TBD	TBD	SUPPLIED BY OWNER (OWNER TO PROVIDE FINAL APPROVAL AND COORDINATE W/ GENERAL CONTRACTOR)

HARDWARE SCHEDULE

ITEM TYPE	ITEM No.	DESCRIPTION	MANUFACTURER	COLOR / FINISH	MODEL No.	COMMENTS
CABINET KILLS	HO-01	SMALL PULL (1/2" HGT)	HAYELE	STAINLESS STEEL / MATT	117 05 003	BY MILLWOMEN
CABINET KILLS	HO-02	LONG PULL (1/2" HGT)	HAYELE	STAINLESS STEEL / MATT	117 05 003	BY MILLWOMEN (PROVIDE STANDARD HEAVY-DUTY TYPE HINGE)
CABINET EUROPEAN HINGES	NA	COMBINED EUROPEAN HINGES	NA	FROSTED NICKEL (OR EQUAL)	NA	BY MILLWOMEN (PROVIDE STANDARD H-AND SELF-CLOSING GLIDE)
SELF-CLOSING GLIDES	NA	DRAMEN GLIDES	NA	FROSTED NICKEL (OR EQUAL)	NA	BY MILLWOMEN (PROVIDE STANDARD LEVELER AS REQUIRED)
LEVELERS	NA	CABINET FLOOR LEVELER	NA	STAINLESS STEEL / MATT	NA	BY MILLWOMEN
WASTE BIN GLIDES	NA	DOUBLE WASTE BIN SOFT CLOSE GLIDE	HAYELE	FROSTED NICKEL	USC15-2-30P1 / A053 11327	BY MILLWOMEN

REVISION 1: 10. 11. 2010



PROJECT:  
LITTLE SAINT  
JAMES  
No. 6A RED HOOK QUARTER  
ST. THOMAS, U.S. VIRGIN ISLANDS



- ARCHITECT OF RECORD:
- PHASE
  - SCHEMATIC DESIGN
  - DESIGN DEVELOPMENT
  - PERMIT DOCUMENT
  - BID DOCUMENT
  - CONSTRUCTION DOCUMENT
  - PROGRESS / REVIEW DOCUMENT
  - PRESENTATION

NO.	DATE	REVISION
1	09.07.10	ISSUE FOR CONSTRUCTION
2	09.08.10	ISSUE FOR REVIEW
3	09.09.10	ISSUE FOR REVIEW
4	09.10.10	ISSUE FOR REVIEW
5	09.16.10	ISSUE FOR REVIEW
6	09.20.10	ISSUE FOR REVIEW
7	09.22.10	ISSUE FOR REVIEW
8	09.23.10	ISSUED FOR BIDDING
10.11.10 REVISION 1		

SCHEDULES AND NOTES

SCALE: AS NOTED

PROJECT: ID0.04

DATE: 09.07.2010  
DRAWN BY: J.P.  
CHECKED BY: MZ



PROJECT:  
**LITTLE SAINT**  
**JAMES**  
 No. 6A RED HOOK QUARTER  
 ST. THOMAS, U.S. VIRGIN ISLANDS

REPAIR

ARCHITECT OF RECORD



- PHASE
- SCHEMATIC DESIGN
  - DESIGN DEVELOPMENT
  - PERMIT DOCUMENT
  - BID DOCUMENT
  - CONSTRUCTION DOCUMENT
  - PROGRESS / REVIEW DOCUMENT
  - PRESENTATION

NO.	DATE	DESCRIPTION
1	09.07.10	ISSUE FOR CONSTRUCTION
2	09.08.10	ISSUE FOR REVIEW
3	09.09.10	ISSUE FOR REVIEW
4	09.10.10	ISSUE FOR REVIEW
5	09.16.10	ISSUE FOR REVIEW
6	09.20.10	ISSUE FOR REVIEW
7	09.22.10	ISSUE FOR BIDDING
8	09.23.10	ISSUED FOR BIDDING
REVISION 1: 10. 11. 2010		
10.11.10	REVISION 1	


**ENLARGED**  
**KITCHEN**  
**FLOOR PLAN**

DRAWING TITLE: AS NOTED

**ID5.01A**

SHEET NO. 09.07.2010

DRAWN BY: J.P. CHECKED BY: MZ

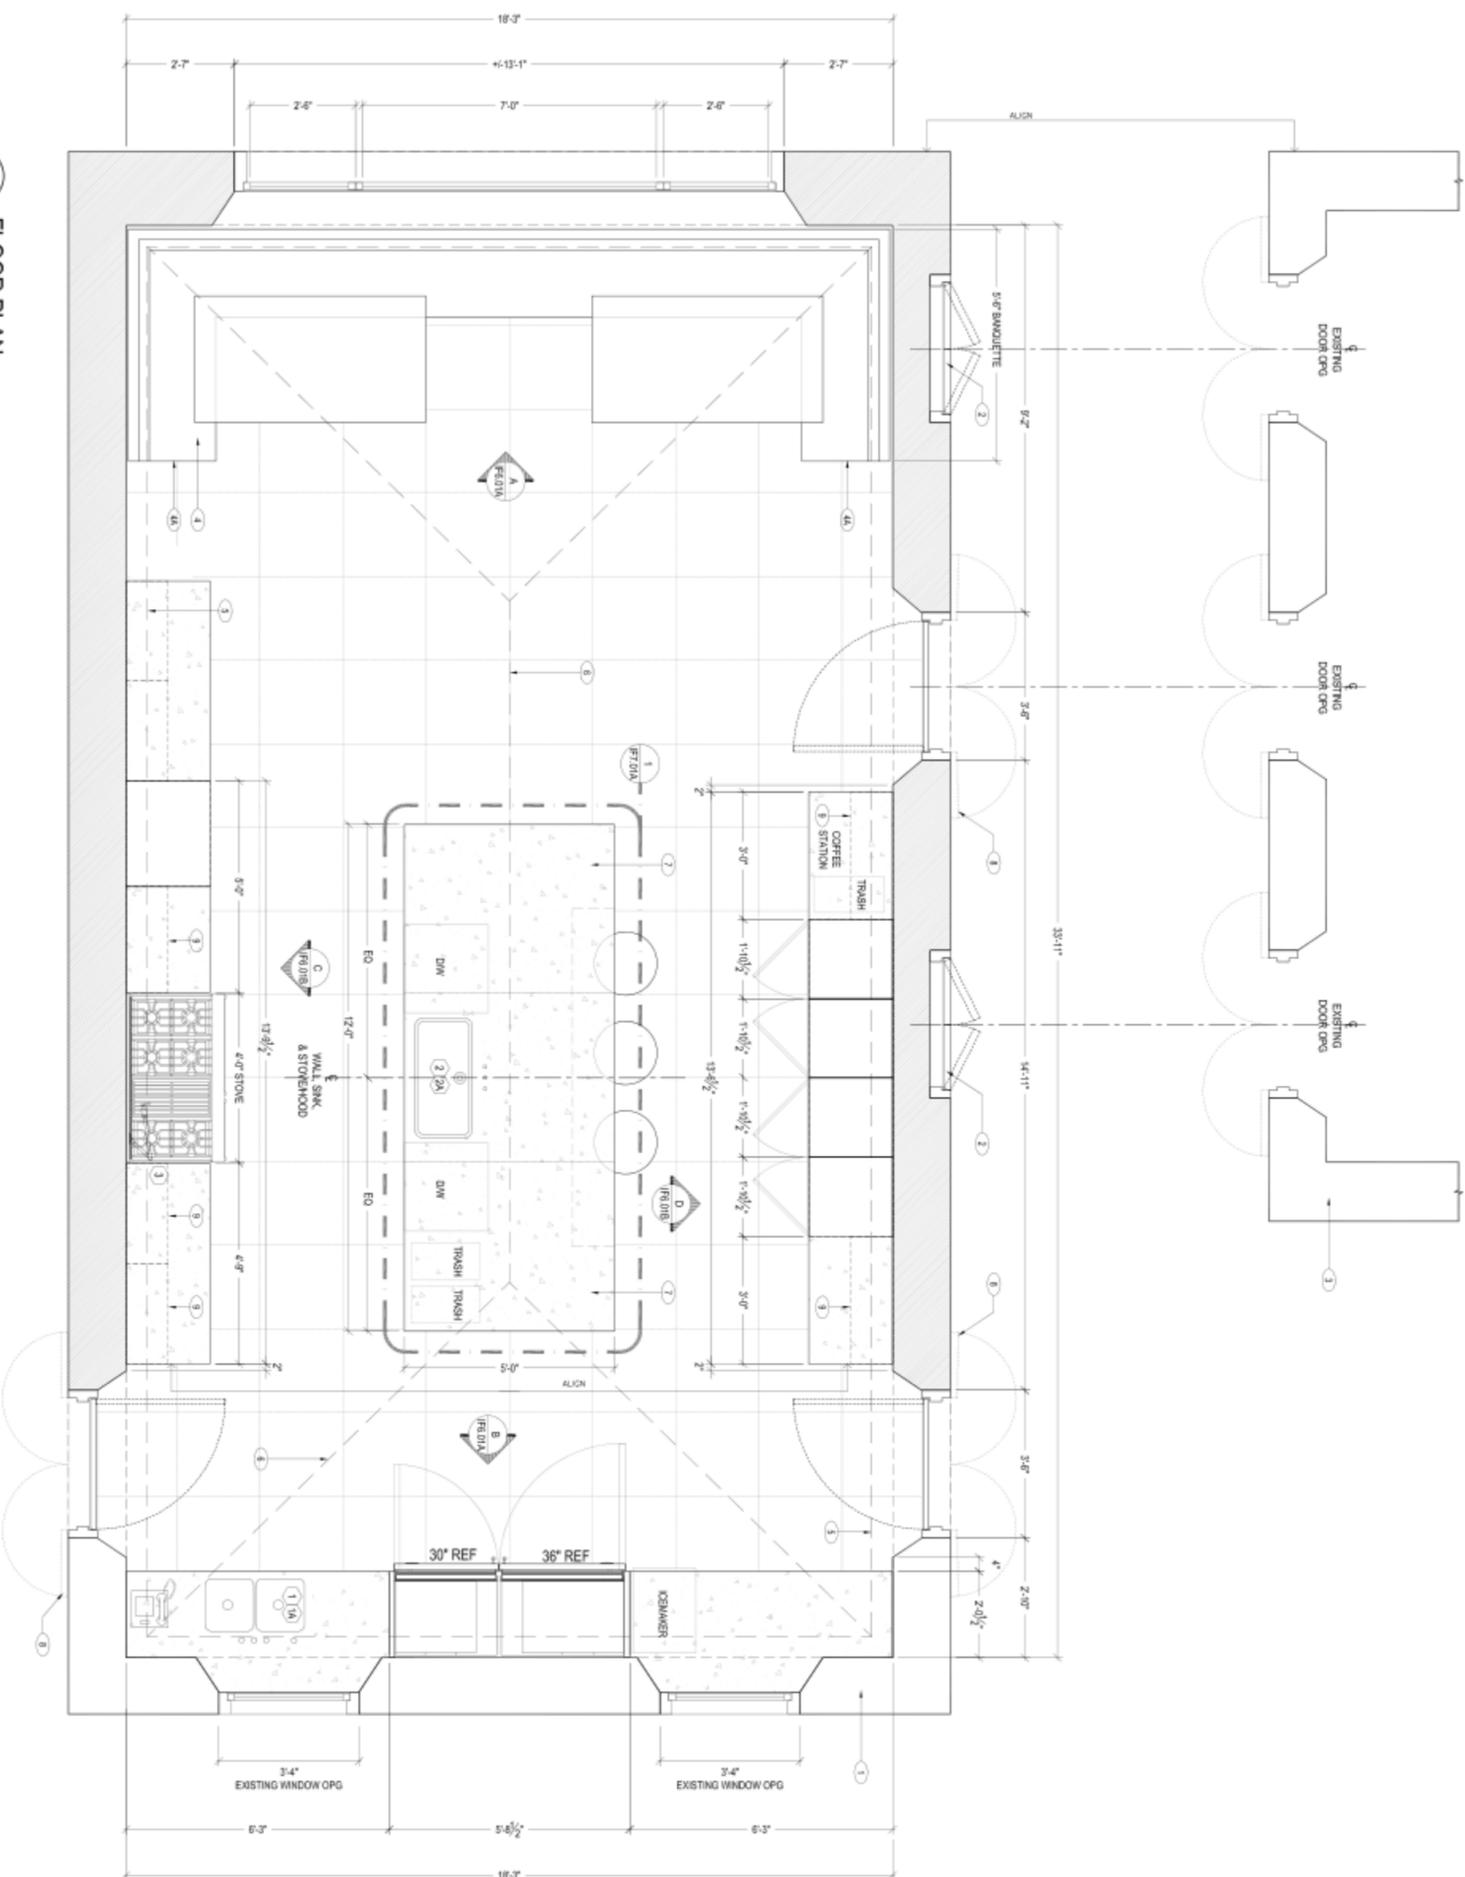

**1 FLOOR PLAN**  
 SCALE 1/2"=1'-0"



**FLOOR PLAN SYMBOLS LEGEND**



	EXISTING PARTITION TO REMAIN
	NEW PARTITION, SEE WALL TYPES FOR CLARIFICATION
	EXISTING FOUNDATION AND FOOTING
	NEW 1-HOUR FIRE RATED PARTITION
	NEW GLASS PARTITIONS
	INDICATES OVERHEAD SOFFITS, MOOD OPENINGS
	INDICATES NEW STONE MILLWORK TOPS
	INDICATES AREAS OF CUSTOM MILLWORK
	DETAIL NUMBER - DRAWING NUMBER SHEET NUMBER
	FLOOR PLAN SHEET NOTE NUMBER, SEE NOTES ON THIS DRAWING

**PLUMBING FIXTURE SCHEDULE**

1	P-01 DOUBLE BASIN SINK UNDERMOUNT
1A	P-01A FAUCET
2	P-02 SINK UNDERMOUNT
2A	P-02A FAUCET
3	P-03 POT FILLER FAUCET

**FLOOR PLAN SHEET NOTES**

1	EXISTING KITCHEN WALL TO REMAIN
2	PAINT SHUTTERS (TO ALIGN WITH OPPOSITE WALL)
3	EXISTING STONE WALLS OF SCREENING ROOM TO REMAIN
4	BUILT-IN BANQUETTE
5	HIDDEN AV CAVITY AT BUILT-IN BANQUETTE (REFER DETAILS)
6	INDICATES DECORATIVE CROWN MOULDING
7	INDICATES CEILING ROOFES
8	CABINETS BELOW CENTER ISLAND
9	WOOD SHUTTERS
10	INDICATES UPPER CABINETS

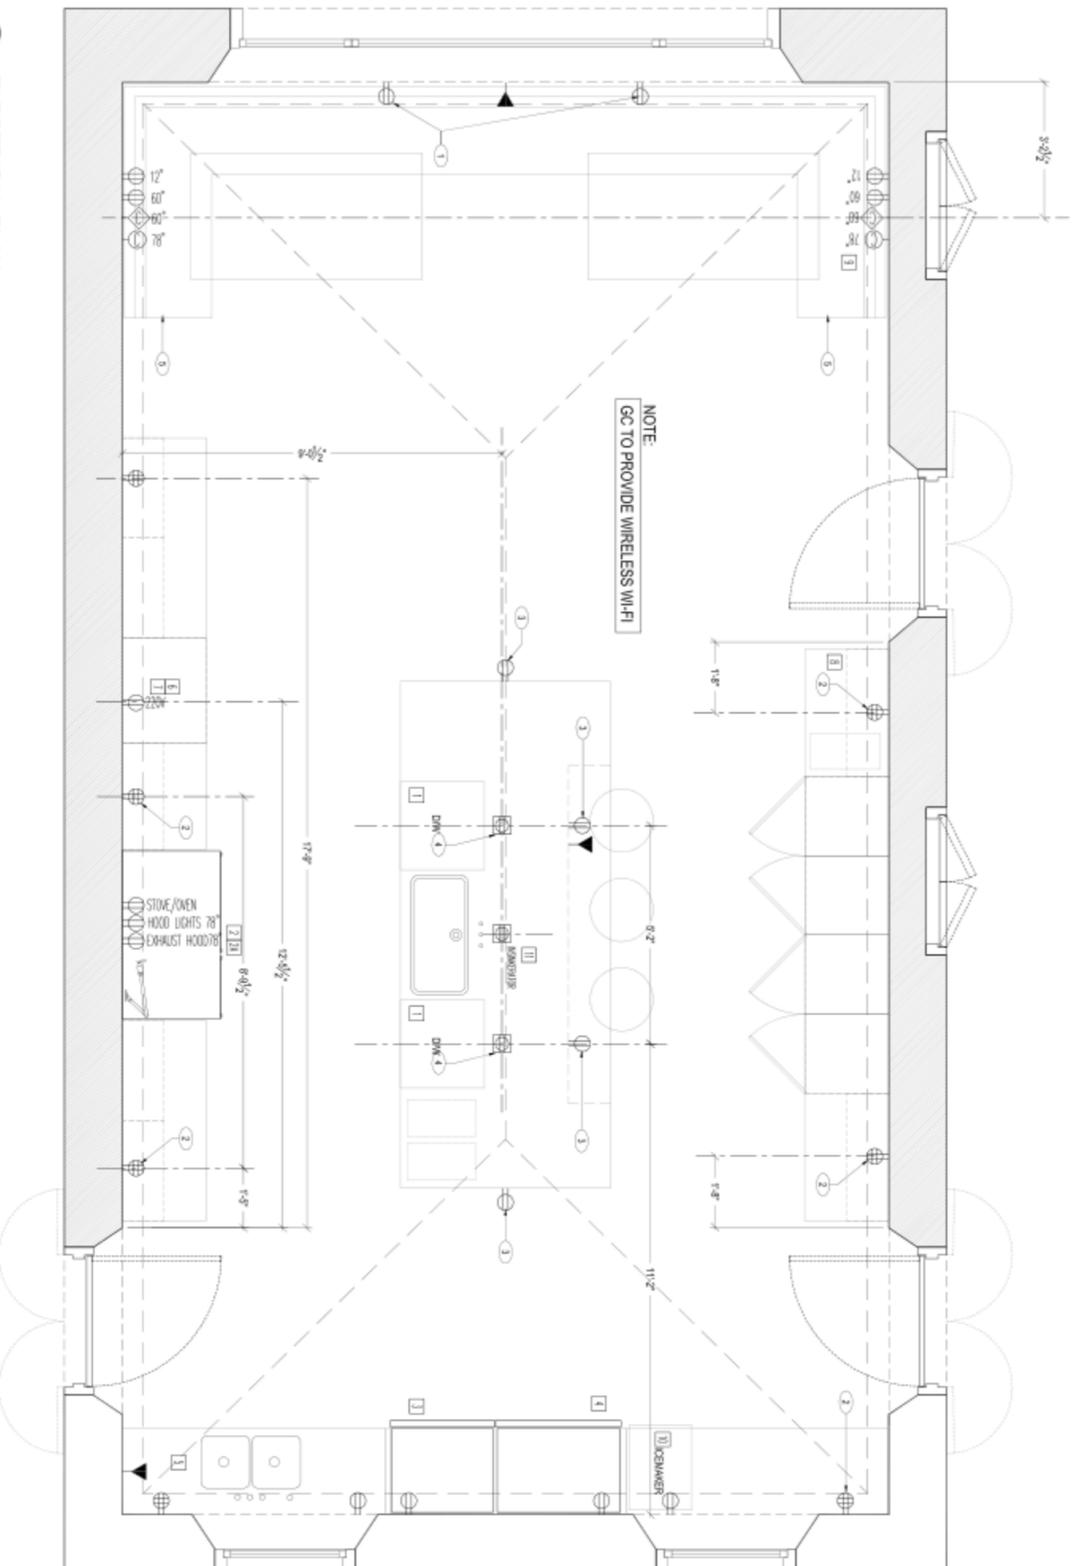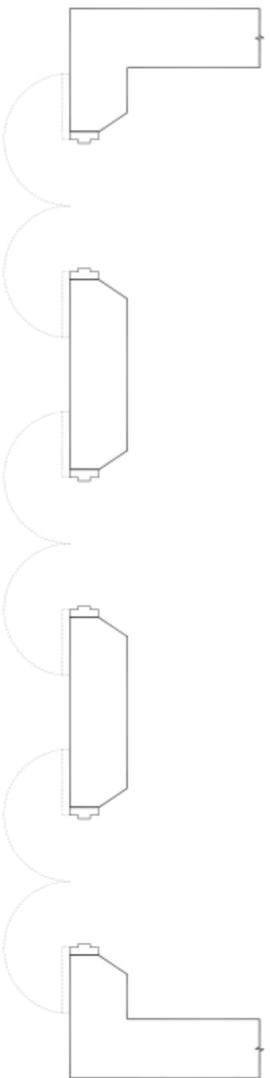

**1 ELECTRICAL PLAN**  
SCALE 1/2"=1'-0"

**ELECTRICAL PLAN SYMBOLS LEGEND**

	WALL MOUNTED DUPLEX RECEPTACLE INSTALLED @ 18" AFF (LION)
	EXTERIOR MOUNTED DUPLEX RECEPTACLE IN WATER RESISTANT COVER
	WALL MOUNTED DUPLEX RECEPTACLE W/ GROUND FAULT INTERRUPTER IN ALL WET LOCATIONS
	WALL MOUNTED SPLIT WIRED RECEPTACLE W/ 11 OUTLET SWITCHED & THE OTHER 4 ALWAYS ENERGIZED
	WALL MOUNTED ISOLATED DUPLEX RECEPTACLE
	WALL MOUNTED RECESSED DUPLEX RECEPTACLE
	WALL MOUNTED ISOLATED SIMPLEX RECEPTACLE
	WALL MOUNTED QUAD RECEPTACLE
	WALL MOUNTED ISOLATED QUAD RECEPTACLE
	WALL MOUNTED RECESSED QUAD RECEPTACLE
	FLUSH FLOOR MOUNTED DUPLEX RECEPTACLE
	FLUSH FLOOR MOUNTED QUAD RECEPTACLE

	FLUSH FLOOR MOUNTED DEDICATED DUPLEX RECEPTACLE		EQUIPMENT DESIGNATION (REFER TO EQUIPMENT LIST)
	FLUSH FLOOR MOUNTED JUNCTION BOX		INCH RATED NOTCH (REFER ELECTRICAL DWG AND NOTES FOR ADDITIONAL INFO)
	WALL MOUNTED JUNCTION BOX		AMP (REFER TO NOTES FOR ADDITIONAL INFORMATION)
	FLUSH FLOOR MOUNTED TELEPHONE RECEPTACLE		WALL MOUNTED CABLE TV OUTLET
	FLUSH FLOOR MOUNTED DATA RECEPTACLE		POWER STRIP HANDHOLD
	FLUSH FLOOR MOUNTED TILE DATA RECEPTACLE		POWER PANEL
	WALL MOUNTED RECESSED CLOCK OUTLET		INTERCOM W/ CAMERA & MONITOR
	FLUSH FLOOR MOUNTED TILE DATA/POWER RECEPTACLE		WALL MOUNTED THERMOSTAT
	WALL MOUNTED TELEPHONE RECEPTACLE		WALL MOUNTED CARD READER
	WALL MOUNTED TILE DATA RECEPTACLE		WALL MOUNTED PUSH BUTTON
	WALL MOUNTED DATA RECEPTACLE		FLUSH FLOOR MOUNTED ISOLATED QUAD RECEPTACLE
	FLUSH FLOOR MOUNTED QUAD RECEPTACLE		

**EQUIPMENT SCHEDULE**


NO.	DESCRIPTION	ELECTRICAL REQUIREMENTS
1	DISHWASHER	OWNER SUPPLIED, REFER SPEC SHEETS
2	REUSE EXISTING STOVE	OWNER SUPPLIED, REFER SPEC SHEETS
3	REUSE STOVE HOOD	OWNER SUPPLIED, REFER SPEC SHEETS
4	3P REFRIGERATION	OWNER SUPPLIED, REFER SPEC SHEETS
5	3P REFRIGERATION	OWNER SUPPLIED, REFER SPEC SHEETS
6	TELEPHONE	OWNER SUPPLIED, REFER SPEC SHEETS
7	COMBO CONNECTION OVER/WINDO	OWNER SUPPLIED, REFER SPEC SHEETS
8	COFFEE MAKER	OWNER SUPPLIED, REFER SPEC SHEETS
9	FLAT SCREEN TV	OWNER SUPPLIED, REFER SPEC SHEETS
10	ICE MAKER	OWNER SUPPLIED, REFER SPEC SHEETS
11	RISHWATER/DISHWASHER DISPOSAL	OWNER SUPPLIED, REFER SPEC SHEETS

- ELECTRICAL PLAN SHEET NOTES**
- PROVIDE SUFFICIENT EXTRA ELECTRICAL CONDUITING FOR ALL LOCATION BRAND BANDOLETTE. POWER & DATA RECEPTACLES WILL ATTACH TO BASE OF BANDOLETTE COMPONENTS ACCORDINGLY.
  - ALL RECEPTACLE ABOVE COUNTER HEIGHT ARE WALL MOUNTED QUAD RECEPTACLE W/ GFI TO BE INSTALLED 42" AFF. (UNLESS OTHERWISE NOTED)
  - PROVIDE DUPLEX RECEPTACLE DIRECTLY BELOW STOVE TOP
  - PROVIDE RECESSED FLOOR POWER AS REQUIRED FOR DISHWASHERS.
  - AV EQUIPMENT LOCATED AT BASE OF BANDOLETTE (SEE DETAILS)


REVISION 1: 10. 11. 2010

<p><b>MARK ZEFF</b></p>	<p>PROJECT: <b>LITTLE SAINT</b> <b>JAMES</b> No. 6A RED HOOK QUARTER 57 THOMAS, U.S. VIRGIN ISLAND</p>	<p>ARCHITECT OF RECORD</p>	<p>PHASE</p> <input type="checkbox"/> SCHEMATIC DESIGN <input type="checkbox"/> DESIGN DEVELOPMENT <input type="checkbox"/> PERMIT DOCUMENT <input checked="" type="checkbox"/> BID DOCUMENT <input type="checkbox"/> CONSTRUCTION DOCUMENT <input type="checkbox"/> PROGRESS / REVIEW DOCUMENT <input type="checkbox"/> PRESENTATION															
			<p>REVISIONS</p> <table border="1"> <tr> <td>10.11.10</td> <td>REVISION 1</td> </tr> <tr> <td>09.23.10</td> <td>ISSUED FOR BIDDING</td> </tr> <tr> <td>09.22.10</td> <td>ISSUE FOR REVIEW</td> </tr> <tr> <td>09.20.10</td> <td>ISSUE FOR REVIEW</td> </tr> <tr> <td>09.16.10</td> <td>ISSUE FOR REVIEW</td> </tr> <tr> <td>09.10.10</td> <td>ISSUE FOR REVIEW</td> </tr> <tr> <td>09.09.10</td> <td>ISSUE FOR REVIEW</td> </tr> <tr> <td>09.08.10</td> <td>ISSUE FOR REVIEW</td> </tr> <tr> <td>09.07.10</td> <td>ISSUE FOR CONSTRUCTION</td> </tr> </table>	10.11.10	REVISION 1	09.23.10	ISSUED FOR BIDDING	09.22.10	ISSUE FOR REVIEW	09.20.10	ISSUE FOR REVIEW	09.16.10	ISSUE FOR REVIEW	09.10.10	ISSUE FOR REVIEW	09.09.10	ISSUE FOR REVIEW	09.08.10
10.11.10	REVISION 1																	
09.23.10	ISSUED FOR BIDDING																	
09.22.10	ISSUE FOR REVIEW																	
09.20.10	ISSUE FOR REVIEW																	
09.16.10	ISSUE FOR REVIEW																	
09.10.10	ISSUE FOR REVIEW																	
09.09.10	ISSUE FOR REVIEW																	
09.08.10	ISSUE FOR REVIEW																	
09.07.10	ISSUE FOR CONSTRUCTION																	
<p>SCALE: AS NOTED</p> <p><b>ID5.01B</b></p> <p>DATE: 09.07.2010</p> <p>DRAWN BY: J.P. CHECKED BY: NZ</p>		<p>ENLARGED KITCHEN ELECTRICAL PLAN</p>																




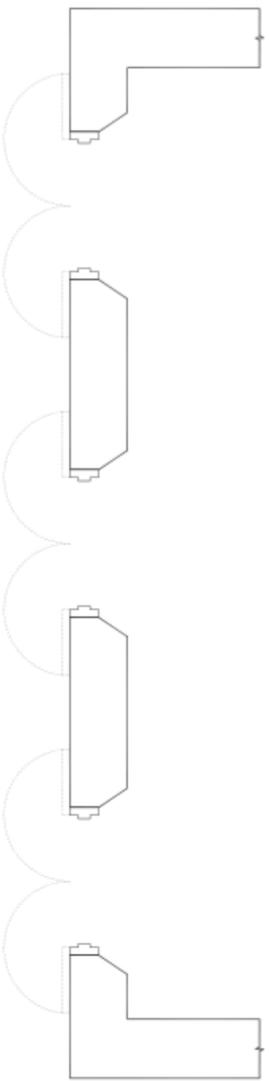

**1 FINISHES PLAN**  
SCALE: 1/2"=1'-0"

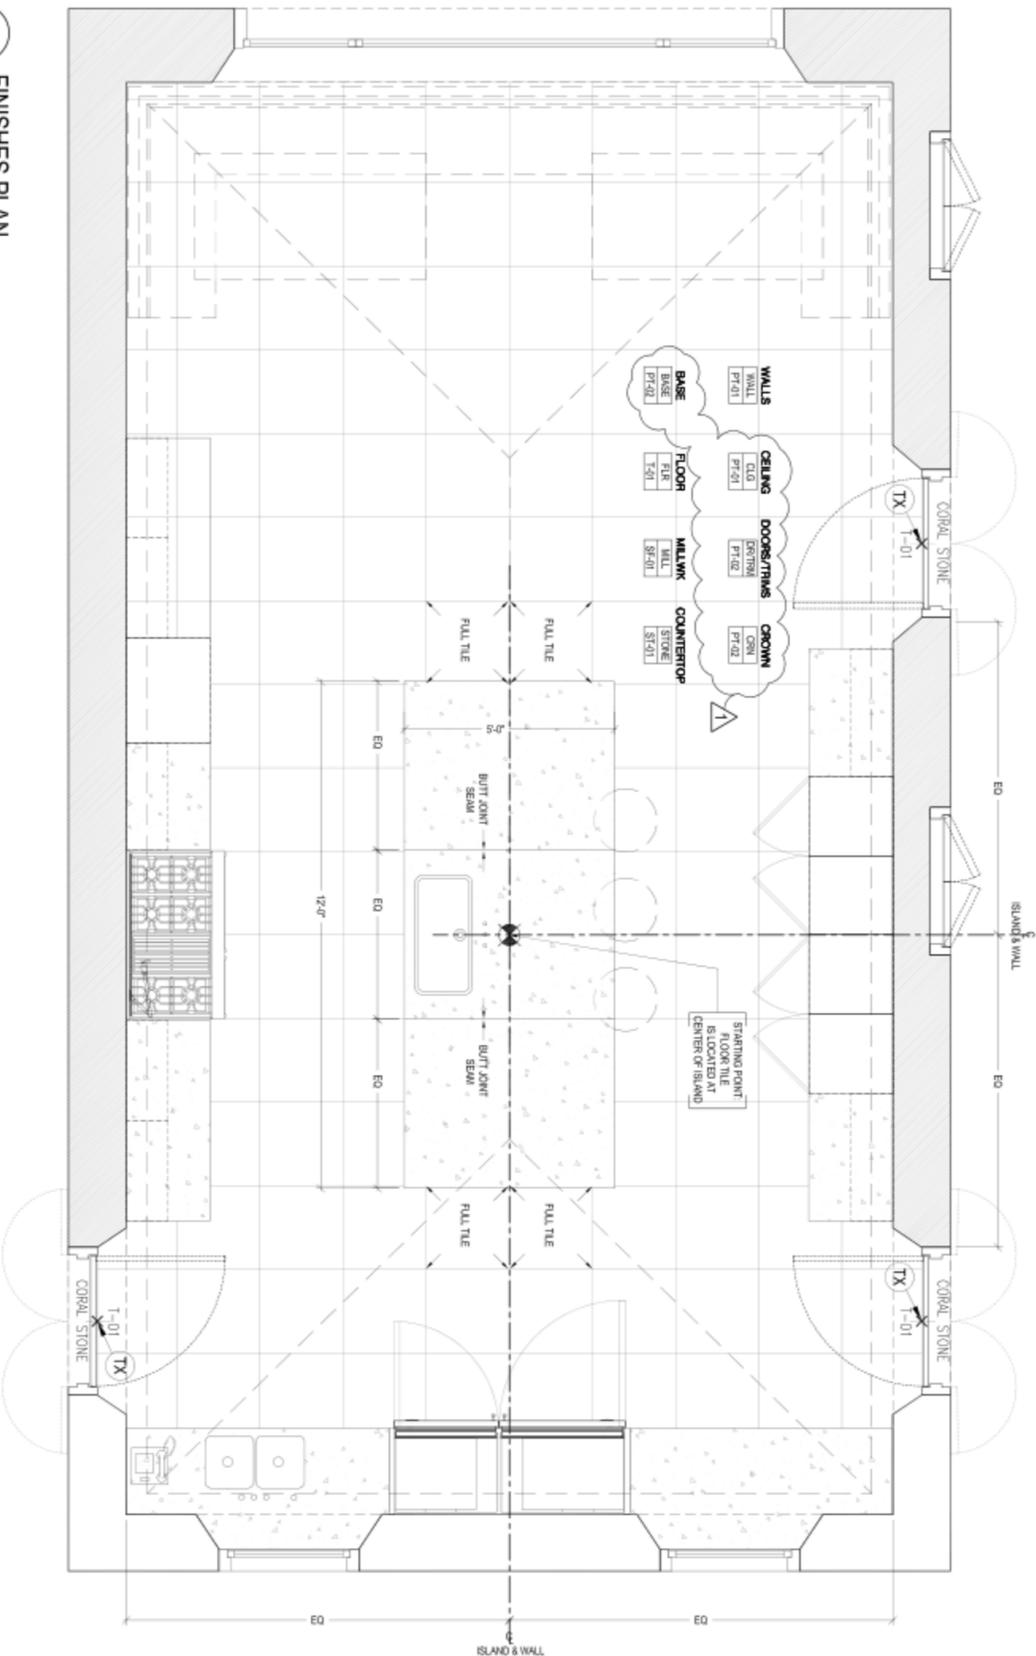

**FINISHES PLAN SYMBOLS LEGEND**

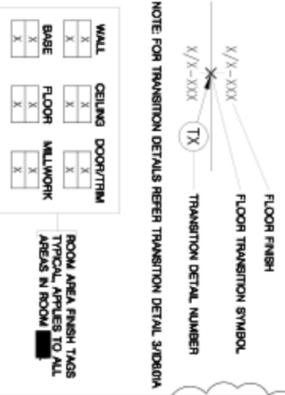

NOTE FOR TRANSITION DETAILS REFER TRANSITION DETAIL 300808A

**FINISHES SCHEDULE**

FLOOR FINISHES	WALL FINISHES	CEILING FINISHES	BASE FINISHES	DOORS/TRIMS	CROWN FINISHES	MISCELLANEOUS FINISHES
ITEM: 3024 STONE TILE MANUFACTURER: CIESA/STONE COLOR/STYLE: PURE WHITE / POLISHED PRODUCT: 31141	ITEM: PAINT MANUFACTURER: BENJAMIN MOORE COLOR/STYLE: SUPER WHITE PRODUCT: FLAT	ITEM: PAINT MANUFACTURER: BENJAMIN MOORE COLOR/STYLE: SUPER WHITE PRODUCT: FLAT	ITEM: PAINT MANUFACTURER: BENJAMIN MOORE COLOR/STYLE: SUPER WHITE PRODUCT: SEMI-GLOSS	ITEM: PAINT MANUFACTURER: BENJAMIN MOORE COLOR/STYLE: SUPER WHITE PRODUCT: SEMI-GLOSS	ITEM: PAINT MANUFACTURER: BENJAMIN MOORE COLOR/STYLE: SUPER WHITE PRODUCT: SEMI-GLOSS	ITEM: CABINETS EXTERIOR MANUFACTURER: BY MILLWORKER COLOR/STYLE: MATCH CONTROL SAMPLE PRODUCT: N/A  ITEM: STONE COUNTERTOPS & BACKSPLASH MANUFACTURER: CIESA/STONE COLOR/STYLE: EGGSHELL / POLISHED PRODUCT: 41141

**FINISHES PLAN SHEET NOTES**

⊖ NOT USED

REVISION 1: 10. 11. 2010



PROJECT:  
**LITTLE SAINT**  
**JAMES**  
No. 6A RED HOOK QUARTER  
ST. THOMAS, U.S. VIRGIN ISLANDS

ARCHITECT OF RECORD:



- PHASE
- SCHEMATIC DESIGN
  - DESIGN DEVELOPMENT
  - PERMIT DOCUMENT
  - BID DOCUMENT
  - CONSTRUCTION DOCUMENT
  - PROGRESS / REVIEW DOCUMENT
  - PRESENTATION

NO.	DATE	REVISION
1	09.07.10	ISSUE FOR CONSTRUCTION
2	09.08.10	ISSUE FOR REVIEW
3	09.09.10	ISSUE FOR REVIEW
4	09.10.10	ISSUE FOR REVIEW
5	09.16.10	ISSUE FOR REVIEW
6	09.20.10	ISSUE FOR REVIEW
7	09.22.10	ISSUE FOR REVIEW
8	09.23.10	ISSUED FOR BIDDING
Δ	10.11.10	REVISION 1

ENLARGED  
KITCHEN  
FINISHES PLAN


DRAWING TITLE:  
AS NOTED

SHEET NO.:  
**ID5.01D**


SCALE:  
DATE: 09.07.2010  
DRAWN BY: J.P. CHECKED BY: MZ






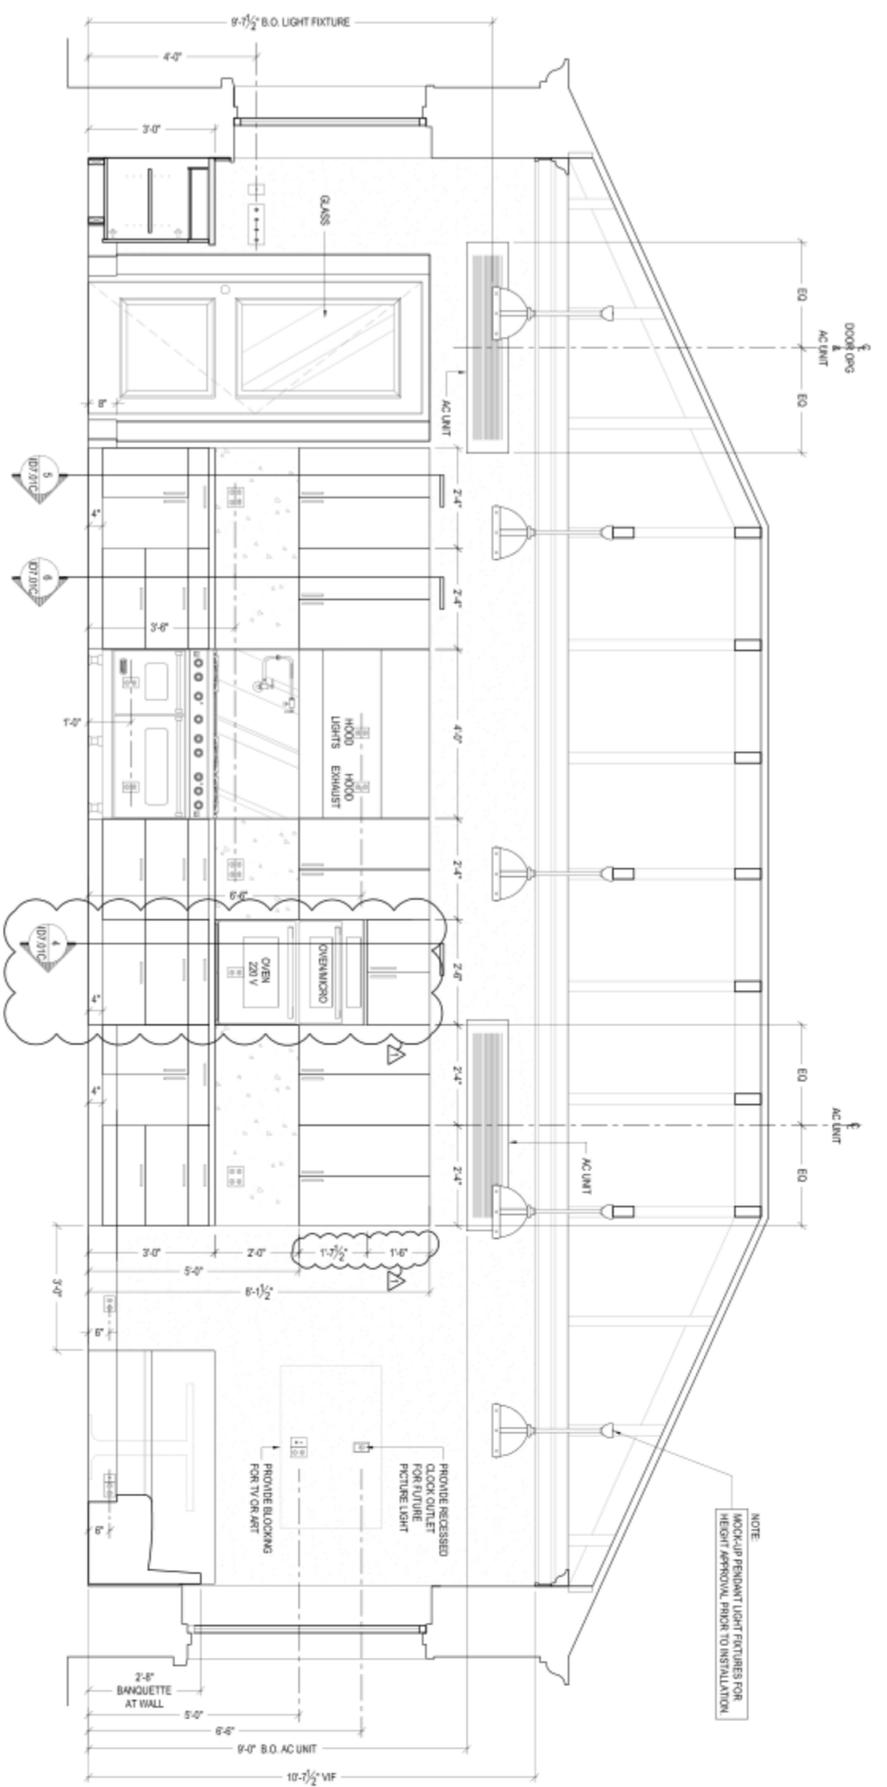

**C** KITCHEN: INTERIOR ELEVATION - LOOKING WEST  
SCALE: 1/2"=1'-0"

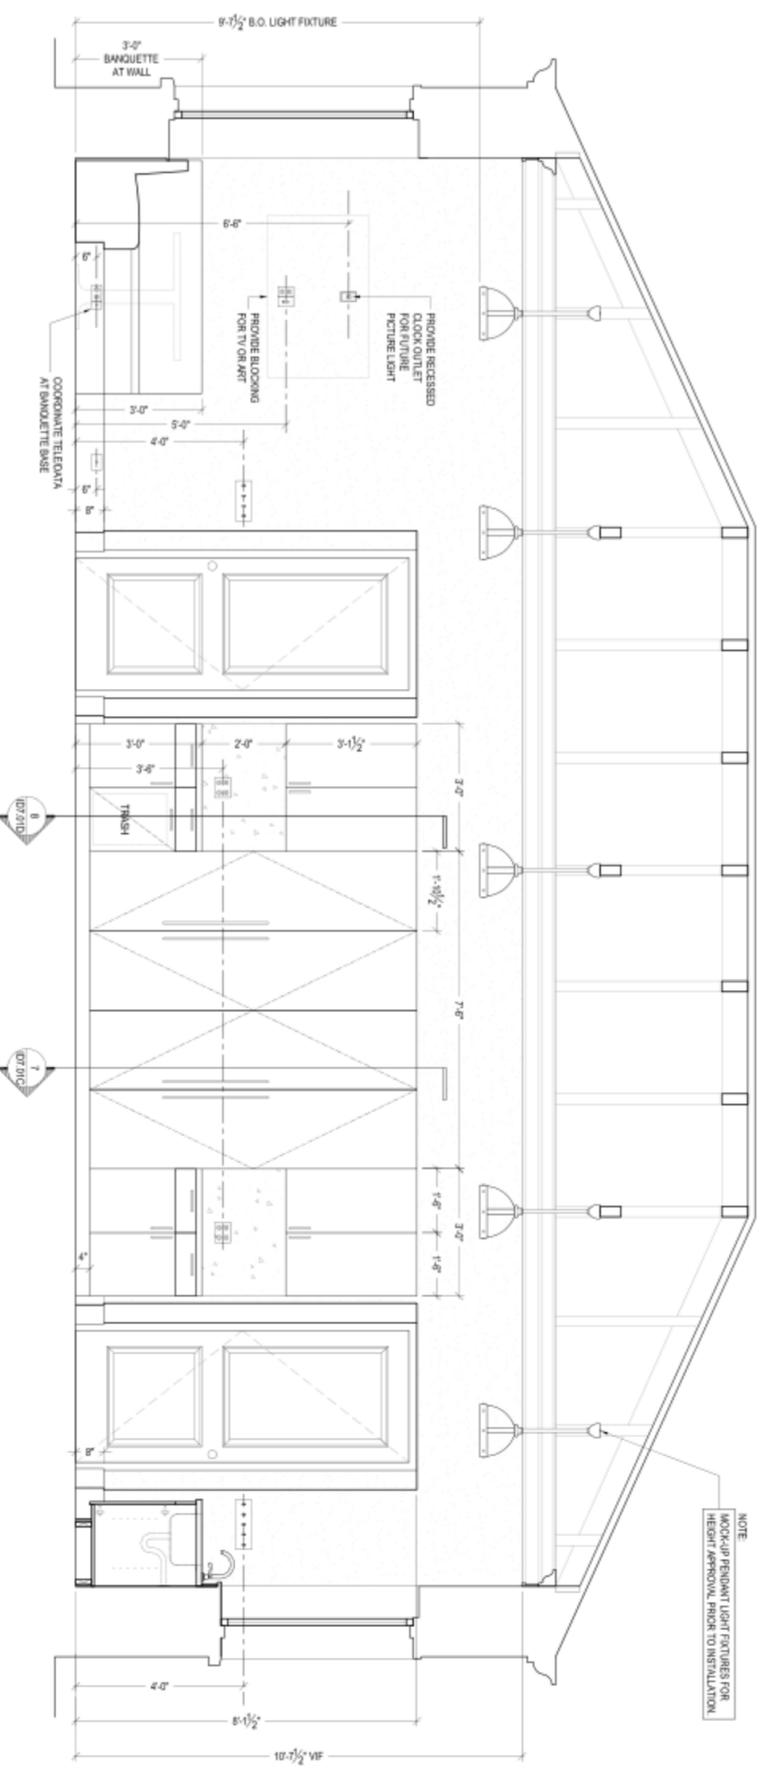

**D** KITCHEN: INTERIOR ELEVATION - LOOKING EAST  
SCALE: 1/2"=1'-0"

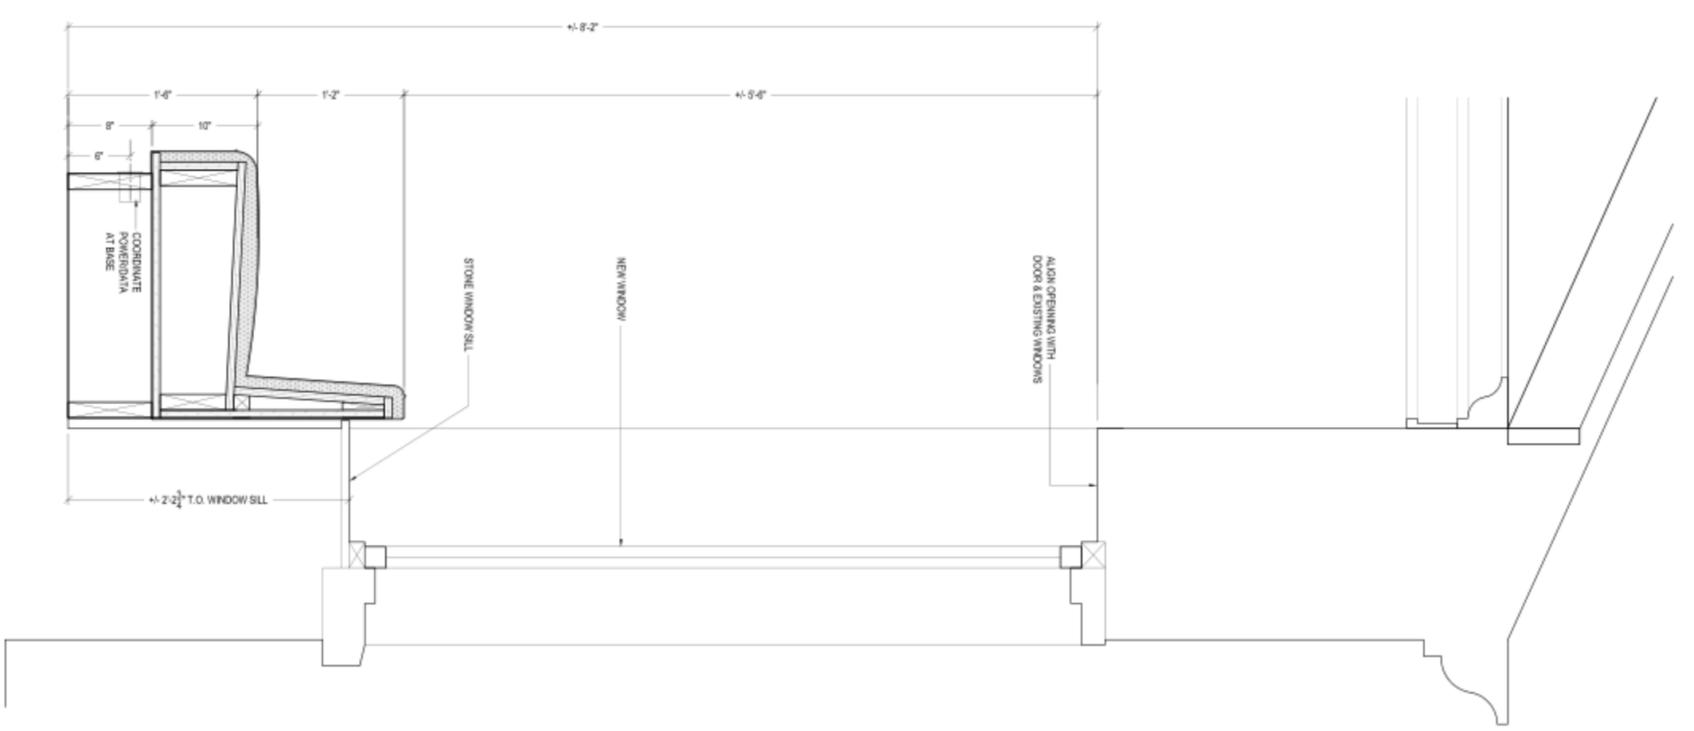

**1** DETAIL: BANQUETTE/WINDOW SECTION  
SCALE: 3/4"=1'-0"

REVISION 1: 10. 11. 2010



PROJECT:  
**LITTLE SAINT**  
**JAMES**  
No. 6A RED HOOK QUARTER  
ST. THOMAS, U.S. VIRGIN ISLANDS

ARCHITECT OF RECORD:

- PHASE:
- SCHEMATIC DESIGN
  - DESIGN DEVELOPMENT
  - PERMIT DOCUMENT
  - BID DOCUMENT
  - CONSTRUCTION DOCUMENT
  - PROGRESS / REVIEW DOCUMENT
  - PRESENTATION

NO.	DATE	DESCRIPTION
1	09.07.10	ISSUE FOR CONSTRUCTION
2	09.08.10	ISSUE FOR REVIEW
3	09.09.10	ISSUE FOR REVIEW
4	09.10.10	ISSUE FOR REVIEW
5	09.16.10	ISSUE FOR REVIEW
6	09.20.10	ISSUE FOR REVIEW
7	09.22.10	ISSUE FOR BIDDING
8	09.23.10	ISSUED FOR BIDDING
10.11.10 REVISION 1		

KITCHEN  
INTERIOR  
ELEVATIONS & DETAILS


DRAWING TITLE:  
AS NOTED

SHEET NO.:  
**ID6.01B**


DATE: 09.07.2010  
DRAWN BY: JP  
CHECKED BY: NZ




EXTERIOR LAQUER FINISH TO MATCH APPROVED CONTROL SAMPLE

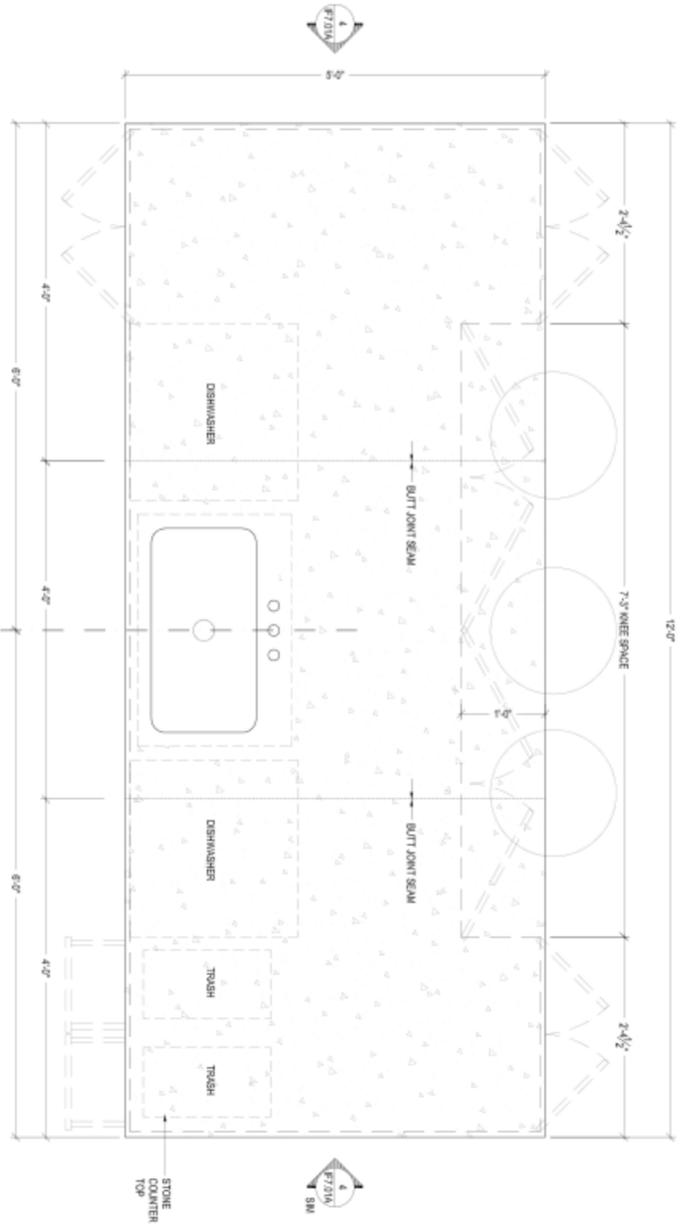


1 DETAIL: KITCHEN ISLAND PLAN  
SCALE: 1/4"=1'-0"

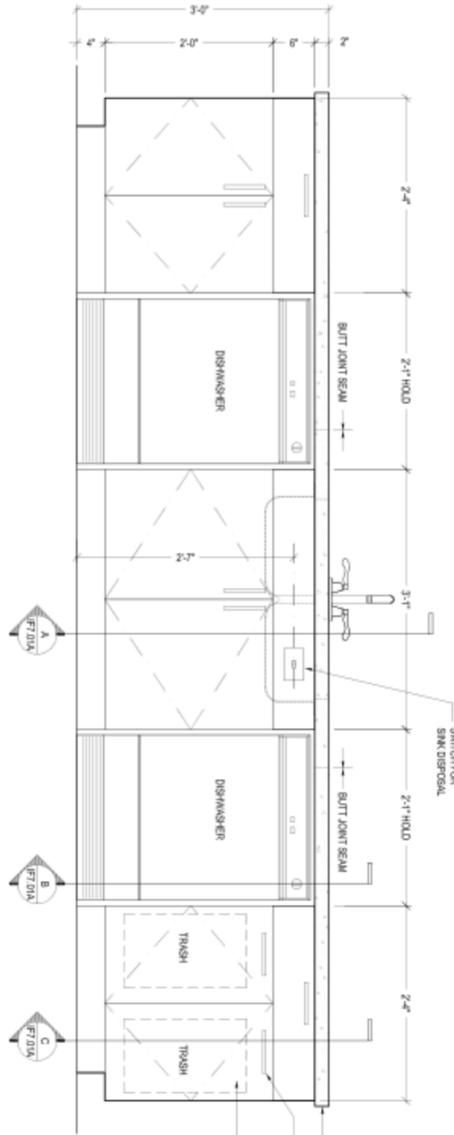


2 DETAIL: KITCHEN ISLAND ELEVATION  
SCALE: 1/4"=1'-0"

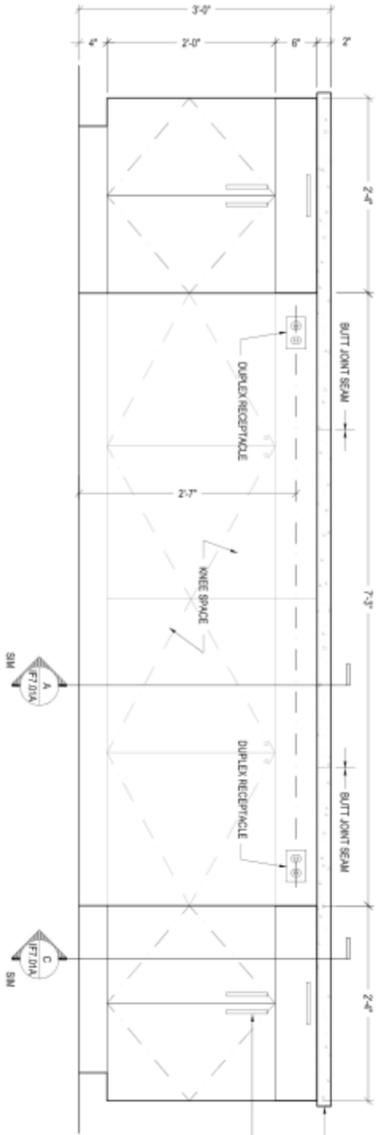

3 DETAIL: KITCHEN ISLAND ELEVATION  
SCALE: 1/4"=1'-0"

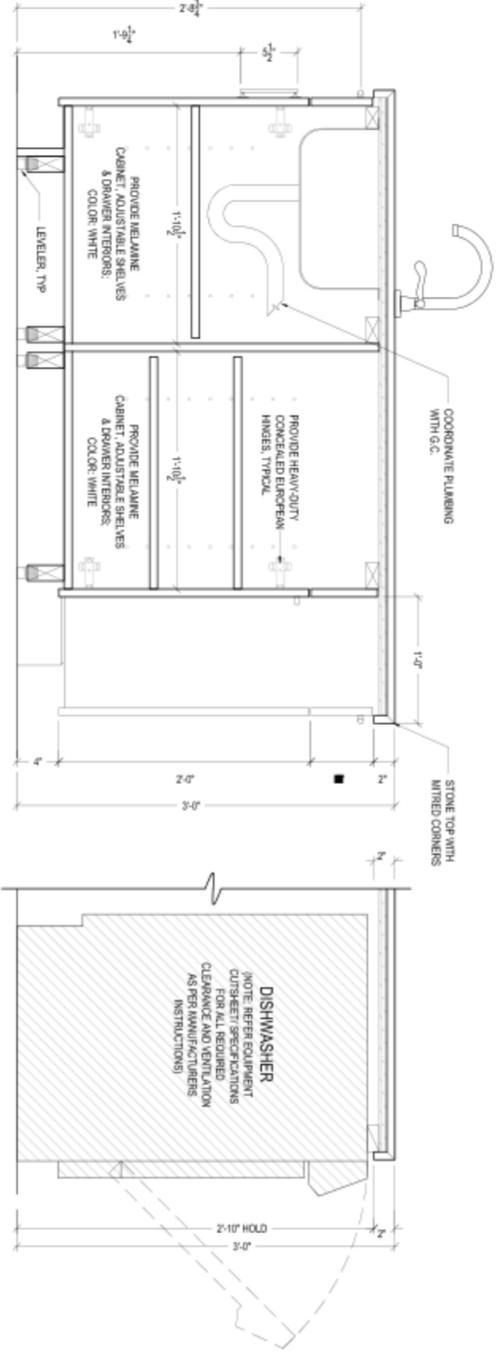


A DETAIL: KITCHEN ISLAND SECTION  
SCALE: 1/12"=1'-0"

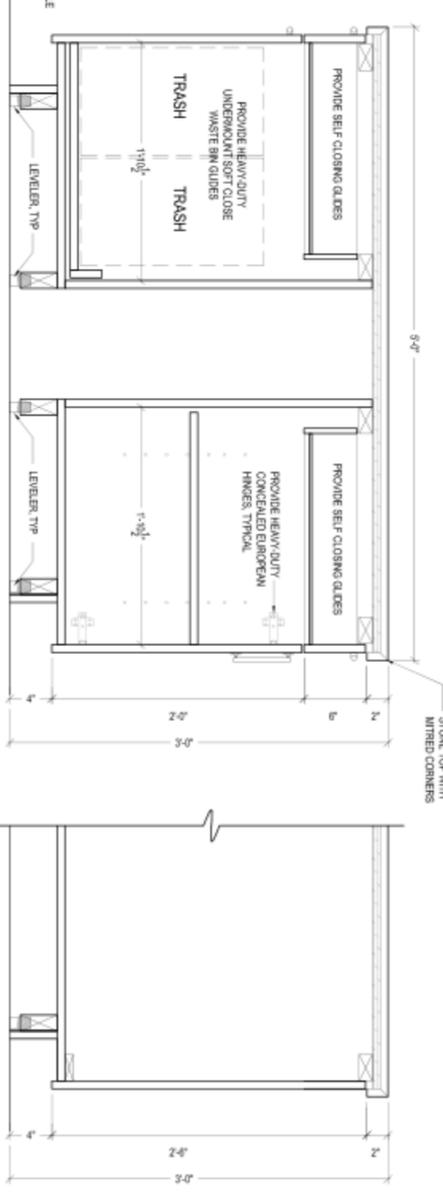

B DETAIL: SECTION  
SCALE: 1/12"=1'-0"

C DETAIL: KITCHEN ISLAND SECTION  
SCALE: 1/12"=1'-0"

D DETAIL: SECTION  
SCALE: 1/12"=1'-0"

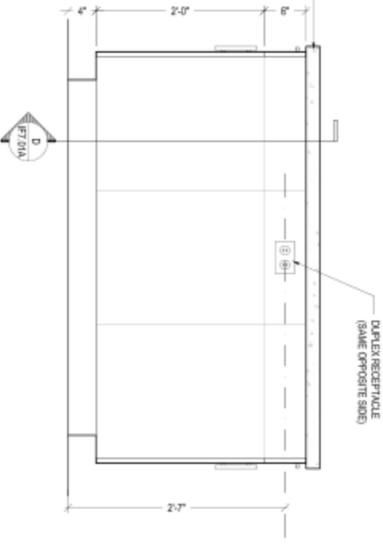

4 DETAIL: KITCHEN ISLAND ELEVATION  
SCALE: 1/4"=1'-0"

REVISION 1: 10. 11. 2010



PROJECT:  
LITTLE SAINT  
JAMES  
No. 6A RED HOOK QUARTER  
ST. THOMAS, U.S. VIRGIN ISLANDS



ARCHITECT OF RECORD:

PHASE:

- SCHEMATIC DESIGN
- DESIGN DEVELOPMENT
- PERMIT DOCUMENT
- BID DOCUMENT
- CONSTRUCTION DOCUMENT
- PROGRESS / REVIEW DOCUMENT
- PRESENTATION

NO.	DATE	REVISION
1	10.11.10	REVISION 1
2	09.23.10	ISSUED FOR BIDDING
3	09.22.10	ISSUE FOR REVIEW
4	09.20.10	ISSUE FOR REVIEW
5	09.16.10	ISSUE FOR REVIEW
6	09.10.10	ISSUE FOR REVIEW
7	09.09.10	ISSUE FOR REVIEW
8	09.08.10	ISSUE FOR REVIEW
9	09.07.10	ISSUE FOR CONSTRUCTION

MILLWORK DETAILS:  
KITCHEN  
ISLAND


DRAWING TITLE:  
AS NOTED

SHEET NO.:  
ID7.01A


DATE: 09.07.2010  
DRAWN BY: J.P. CHECKED BY: MZ

EFTA00727662


EXTERIOR LACQUERED FINISH TO MATCH APPROVED CONTROL SAMPLE

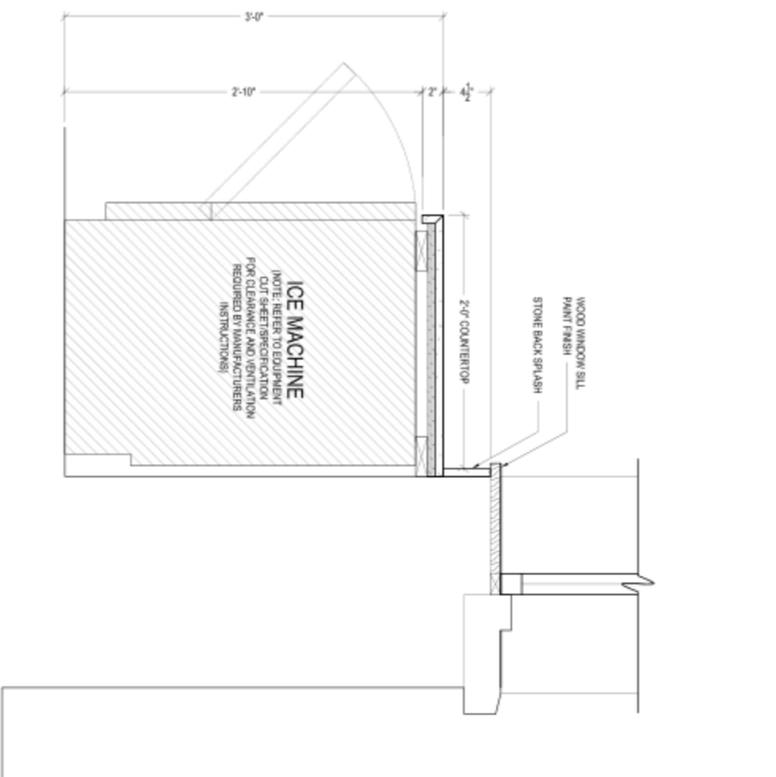


2  
SCALE: 1/12"=1'-0"

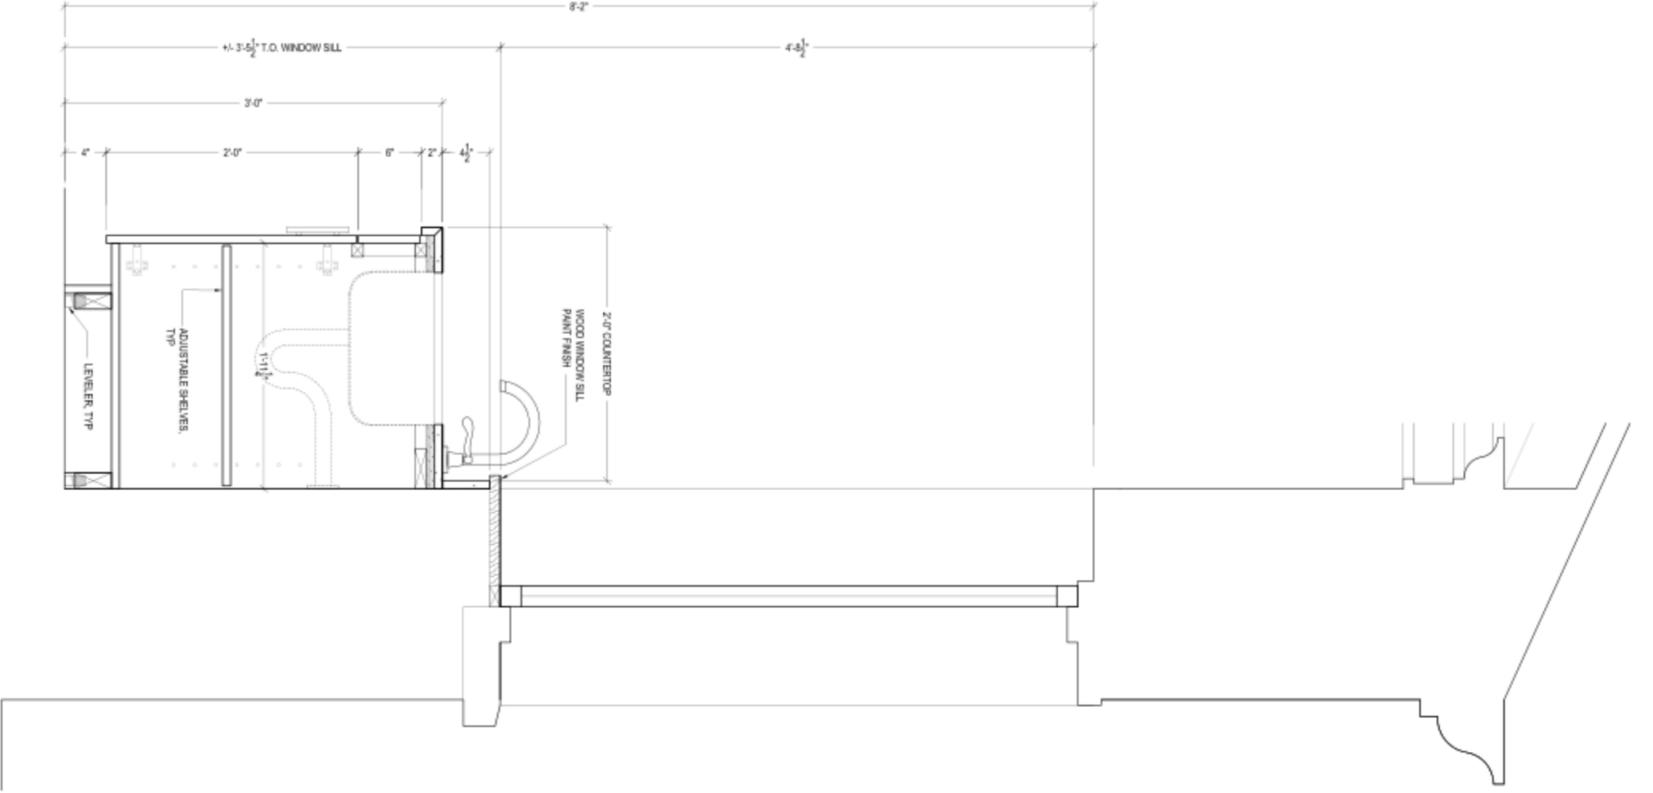

1  
SCALE: 1/12"=1'-0"

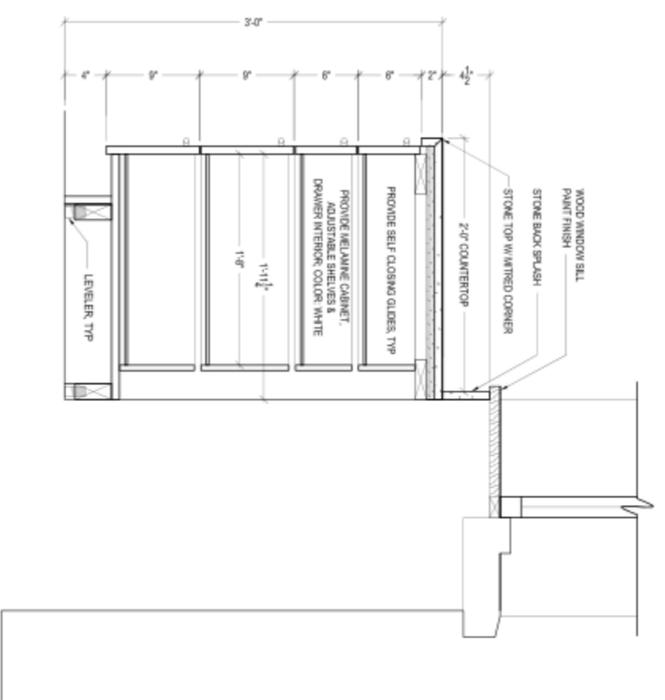

3  
SCALE: 1/12"=1'-0"

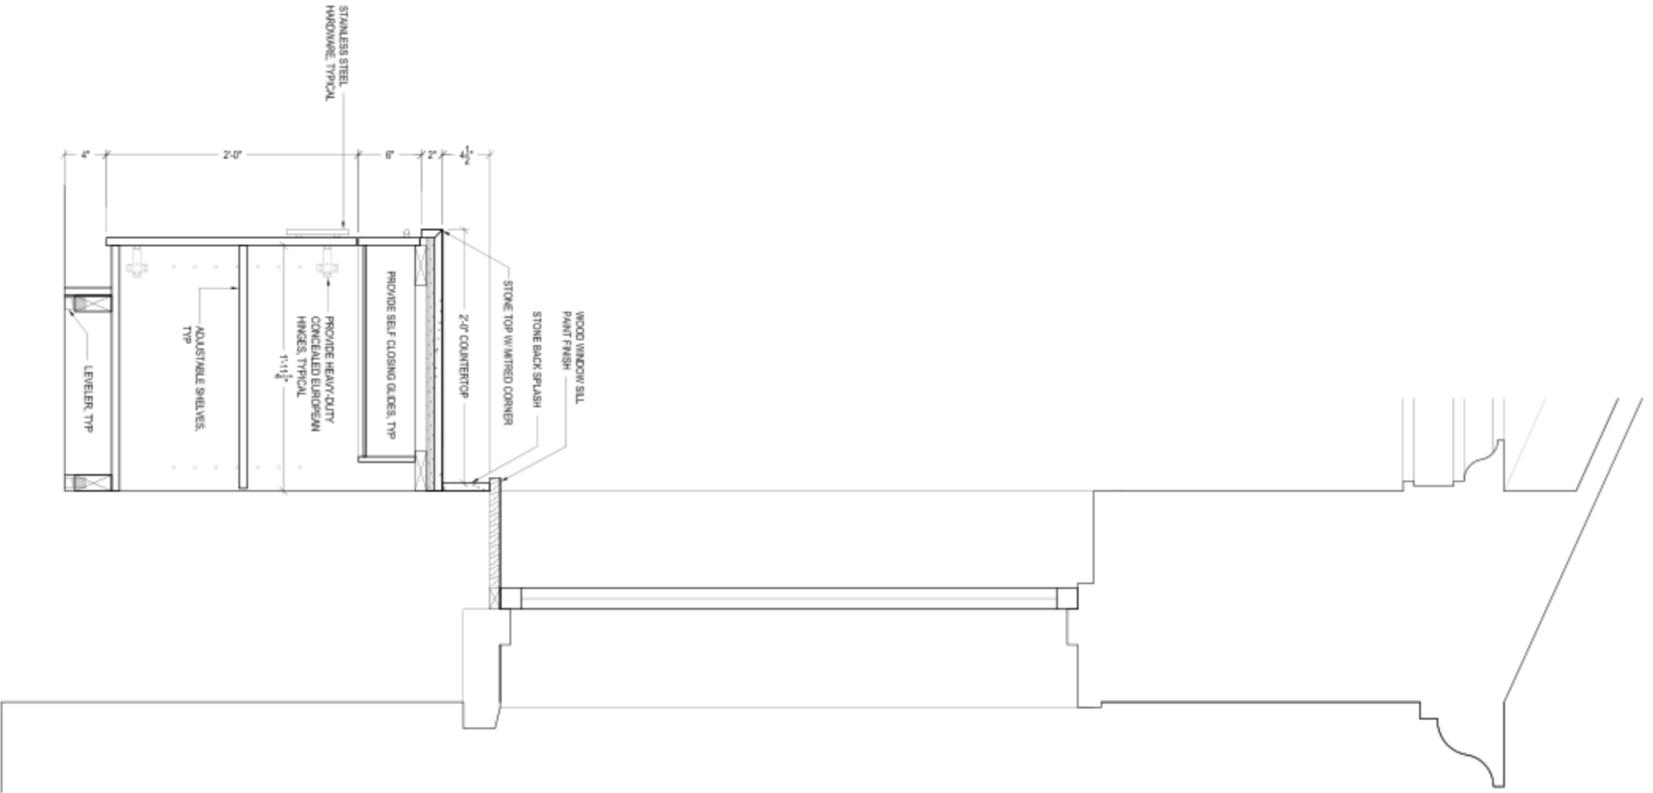

4  
SCALE: 1/12"=1'-0"

REVISION 1: 10. 11. 2010



PROJECT:  
**LITTLE SAINT  
JAMES**  
No. 6A RED HOOK QUARTER  
ST. THOMAS, U.S. VIRGIN ISLANDS

ARCHITECT OF RECORD



- PHASE
- SCHEMATIC DESIGN
  - DESIGN DEVELOPMENT
  - PERMIT DOCUMENT
  - BID DOCUMENT
  - CONSTRUCTION DOCUMENT
  - PROGRESS / REVIEW DOCUMENT
  - PRESENTATION

NO.	DATE	DESCRIPTION
1	09.07.10	ISSUE FOR CONSTRUCTION
2	09.08.10	ISSUE FOR REVIEW
3	09.09.10	ISSUE FOR REVIEW
4	09.10.10	ISSUE FOR REVIEW
5	09.16.10	ISSUE FOR REVIEW
6	09.20.10	ISSUE FOR REVIEW
7	09.22.10	ISSUE FOR REVIEW
8	09.23.10	ISSUED FOR BIDDING
Δ 10.11.10 REVISION 1		

MILLWORK DETAILS:  
KITCHEN  
CABINETS

SCALE: AS NOTED


**ID7.01B**

SHEET NO. 09.07.2010  
DRAWN BY: JP CHECKED BY: NZ


EFTA00727663




EXTERIOR LAQUERED FINISH TO MATCH APPROVED CONTROL SAMPLE

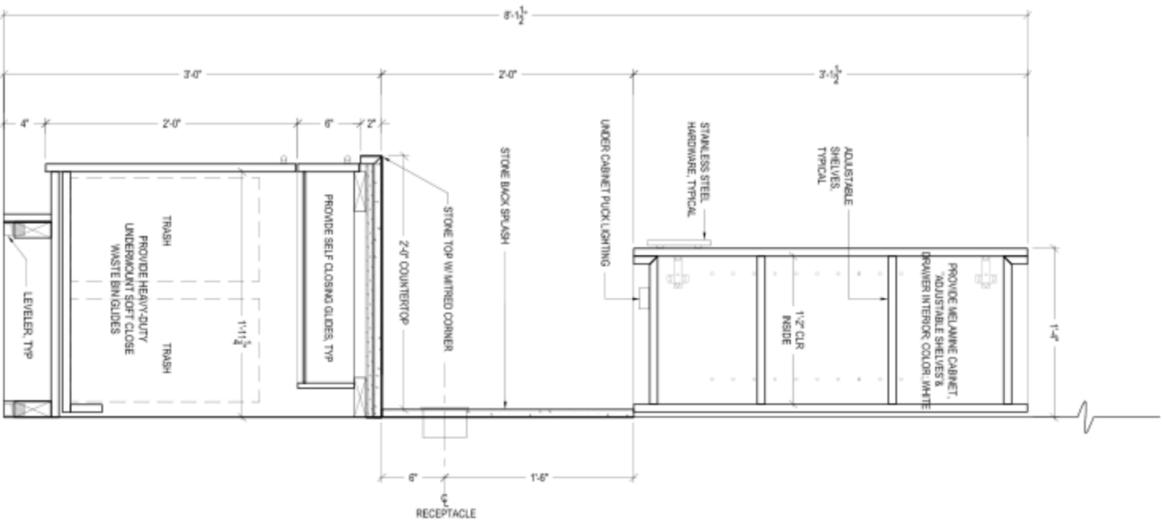

8  
SCALE: 1/12"=1'-0"  
DETAIL: KITCHEN MILLWORK

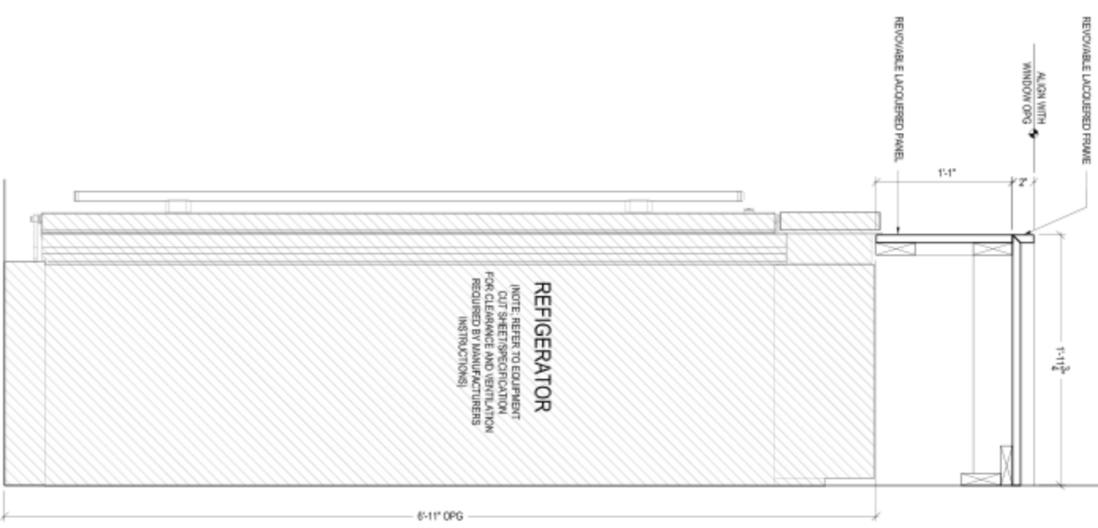

9  
SCALE: 1/12"=1'-0"  
DETAIL: KITCHEN MILLWORK

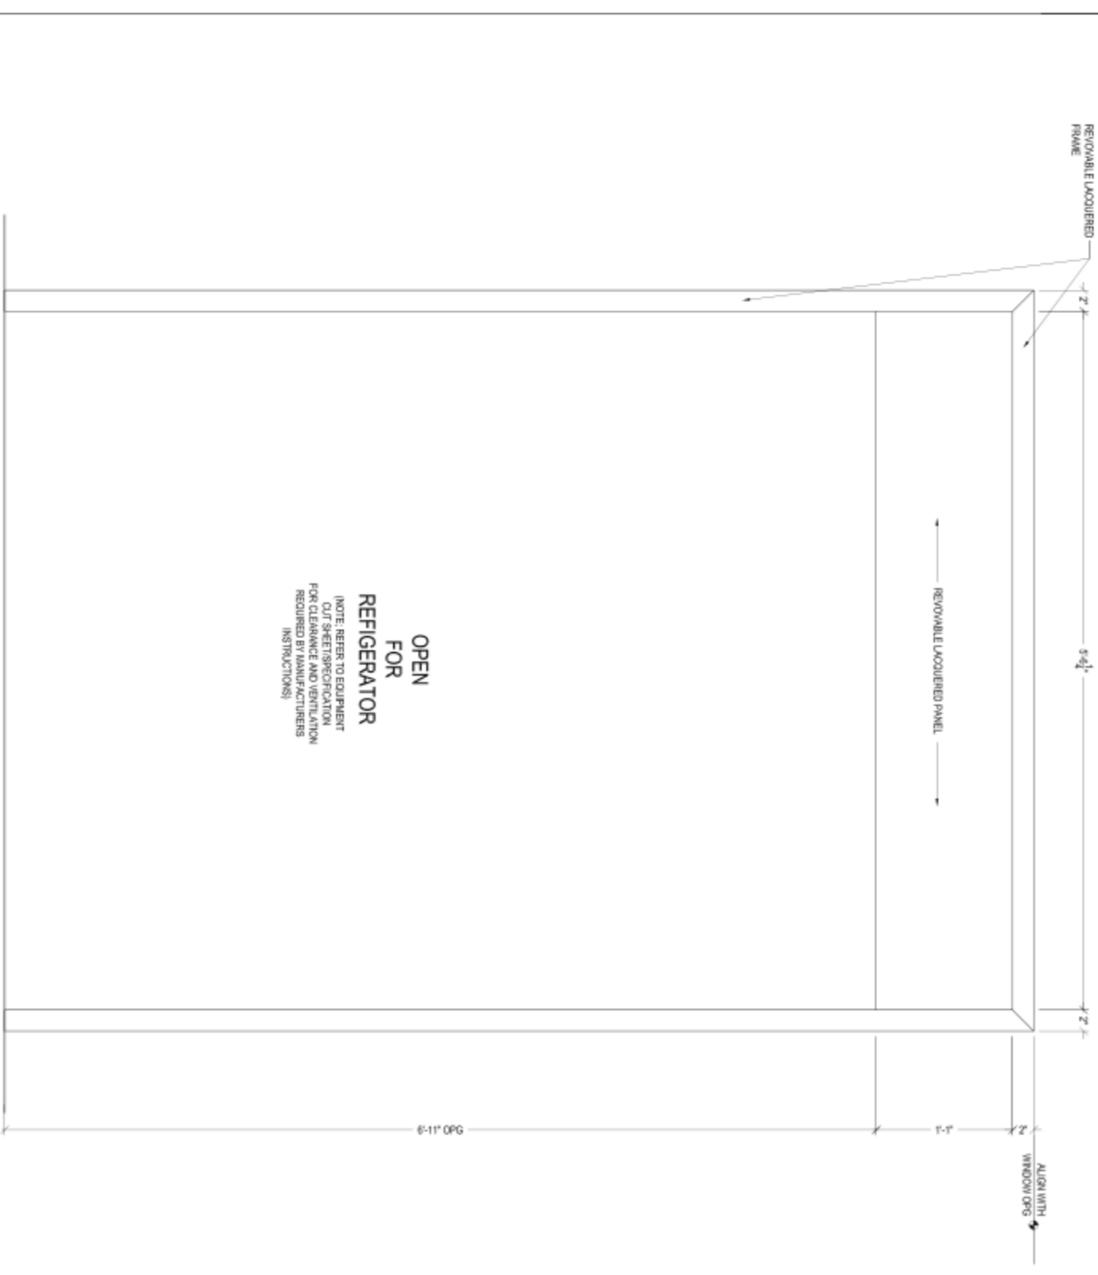

10  
SCALE: 1/12"=1'-0"  
DETAIL: KITCHEN MILLWORK

REVISION 1: 10. 11. 2010



PROJECT:  
**LITTLE SAINT JAMES**  
No. 6A RED HOOK QUARTER  
57 THOMAS, U.S. WINDY HARBOR

ARCHITECT OF RECORD:



- PHASE:
- SCHEMATIC DESIGN
  - DESIGN DEVELOPMENT
  - PERMIT DOCUMENT
  - BID DOCUMENT
  - CONSTRUCTION DOCUMENT
  - PROGRESS / REVIEW DOCUMENT
  - PRESENTATION

NO.	DATE	DESCRIPTION
1	10.11.10	REVISION 1
2	09.23.10	ISSUED FOR BIDDING
3	09.22.10	ISSUE FOR REVIEW
4	09.20.10	ISSUE FOR REVIEW
5	09.16.10	ISSUE FOR REVIEW
6	09.10.10	ISSUE FOR REVIEW
7	09.09.10	ISSUE FOR REVIEW
8	09.08.10	ISSUE FOR REVIEW
9	09.07.10	ISSUE FOR CONSTRUCTION

MILLWORK DETAILS:  
KITCHEN  
CABINETS

DRAWING TITLE:  
AS NOTED

SHEET NO.:  
**ID7.01D**

DATE: 09.07.2010  
DRAWN BY: JP  
CHECKED BY: MZ



MARKZEFF

PROJECT:  
**LITTLE SAINT**  
**JAMES**  
 No. 6A RED HOOK QUARTER  
57 THOMAS ST. WINDY HAVEN

REF PLAN:

ARCHITECT OF RECORD:



REVISION 1: 10. 11. 2010

- PHASE:
- SCHEMATIC DESIGN
  - DESIGN DEVELOPMENT
  - PERMIT DOCUMENT
  - BID DOCUMENT
  - CONSTRUCTION DOCUMENT
  - PROGRESS / REVIEW DOCUMENT
  - PRESENTATION

Δ	10.11.10	REVISION 1
8	09.23.10	ISSUED FOR BIDDING
7	09.22.10	ISSUE FOR REVIEW
6	09.20.10	ISSUE FOR REVIEW
5	09.16.10	ISSUE FOR REVIEW
4	09.10.10	ISSUE FOR REVIEW
3	09.09.10	ISSUE FOR REVIEW
2	09.08.10	ISSUE FOR REVIEW
1	09.07.10	ISSUE FOR CONSTRUCTION

MILLWORK DETAILS:  
**BANQUETTE**


DRAWING TITLE:

SCALE: AS NOTED


SHEET NO.: **ID7.01E**

DATE: 09.07.2010

DRAWN BY: JP CHECKED BY: MZ

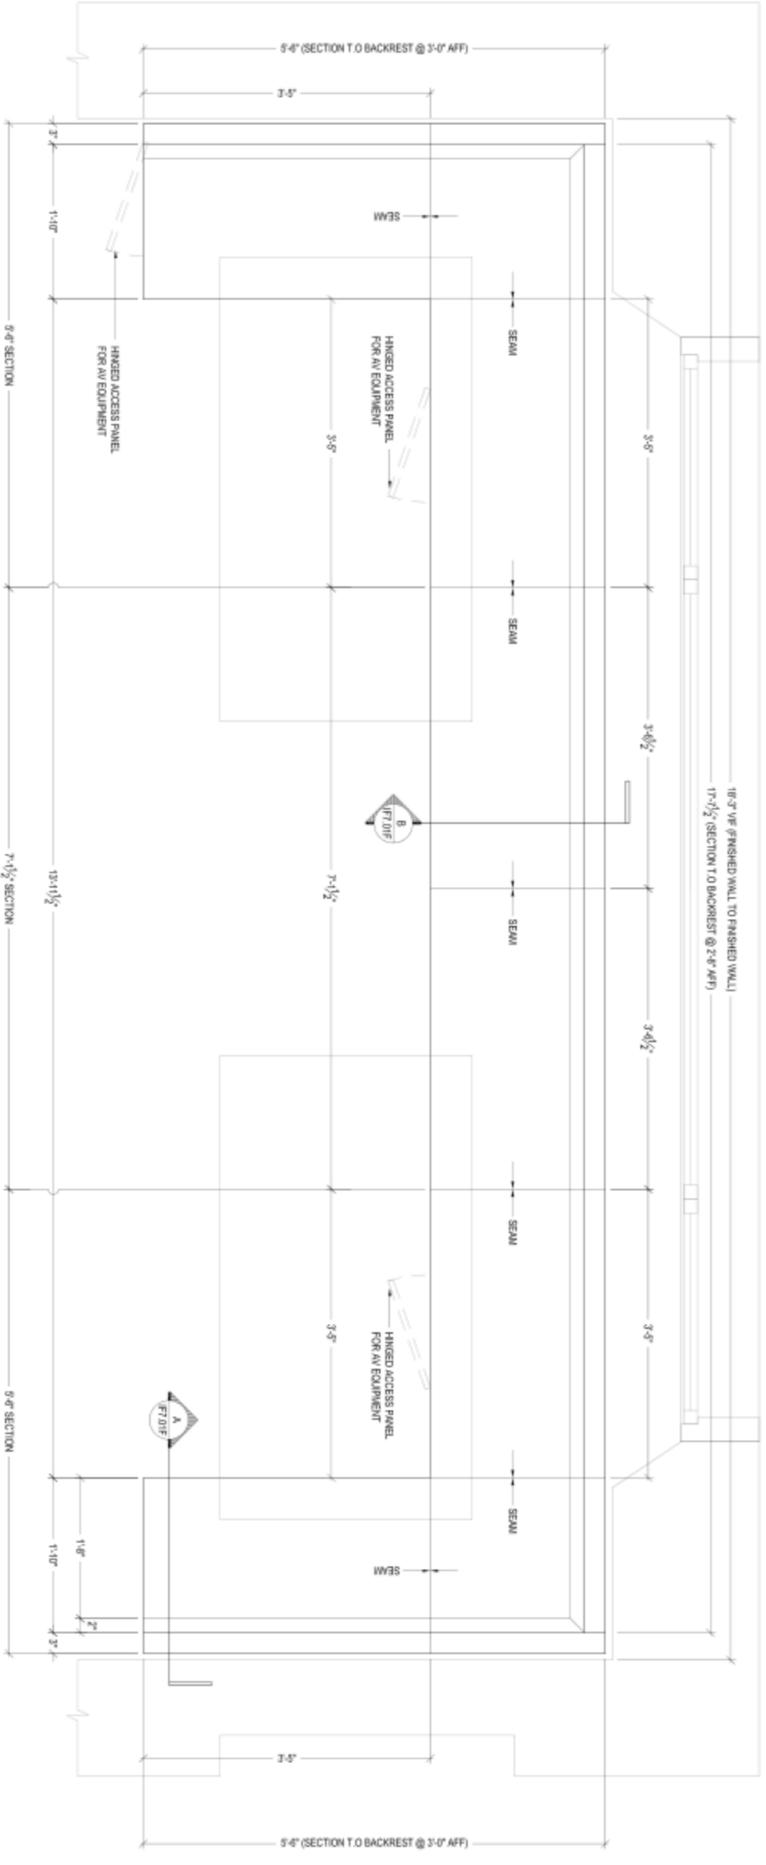

**1**  
 DETAIL: BANQUETTE  
 SCALE: 1"=1'-0"

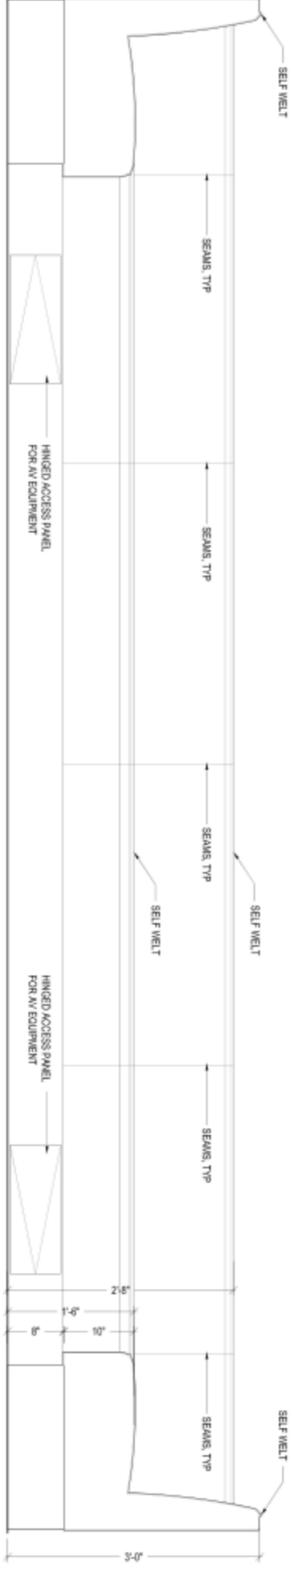

**2**  
 DETAIL: BANQUETTE OPTIONS  
 SCALE: 1"=1'-0"

