



Written dimensions have precedence over scaled dimensions. Contractor shall verify and be responsible for all dimensions and conditions shown on the plans. Field verify all conditions prior to laying out or fabricating work. Bring to the Engineer's attention any deviation from design conditions and field conditions prior to proceeding with any work and cooperate with Engineer to modify such conditions at no additional cost to the owner. Engineer or consultant. Shop drawings must be submitted to the Engineer and reviewed by the Engineer prior to ordering materials, fabrication and delivery to the site, unless otherwise provided for under the specific contractual agreement between the Engineer and Client. Paul Ferreras, PE expressly reserves its common law copyright and other property rights in these documents. These documents are not to be reproduced, changed or copied in any form or manner whatsoever, nor are they to be assigned to a third party without first obtaining the written permission and/or consent of Paul Ferreras, PE. In the event of unauthorized use of these documents by a third party, the third party shall hold Paul Ferreras, PE harmless and agrees to remunerate Paul Ferreras, PE for such use in an amount equal to the original fee for the original documents, plus legal fees, court costs, collection fees and other costs.

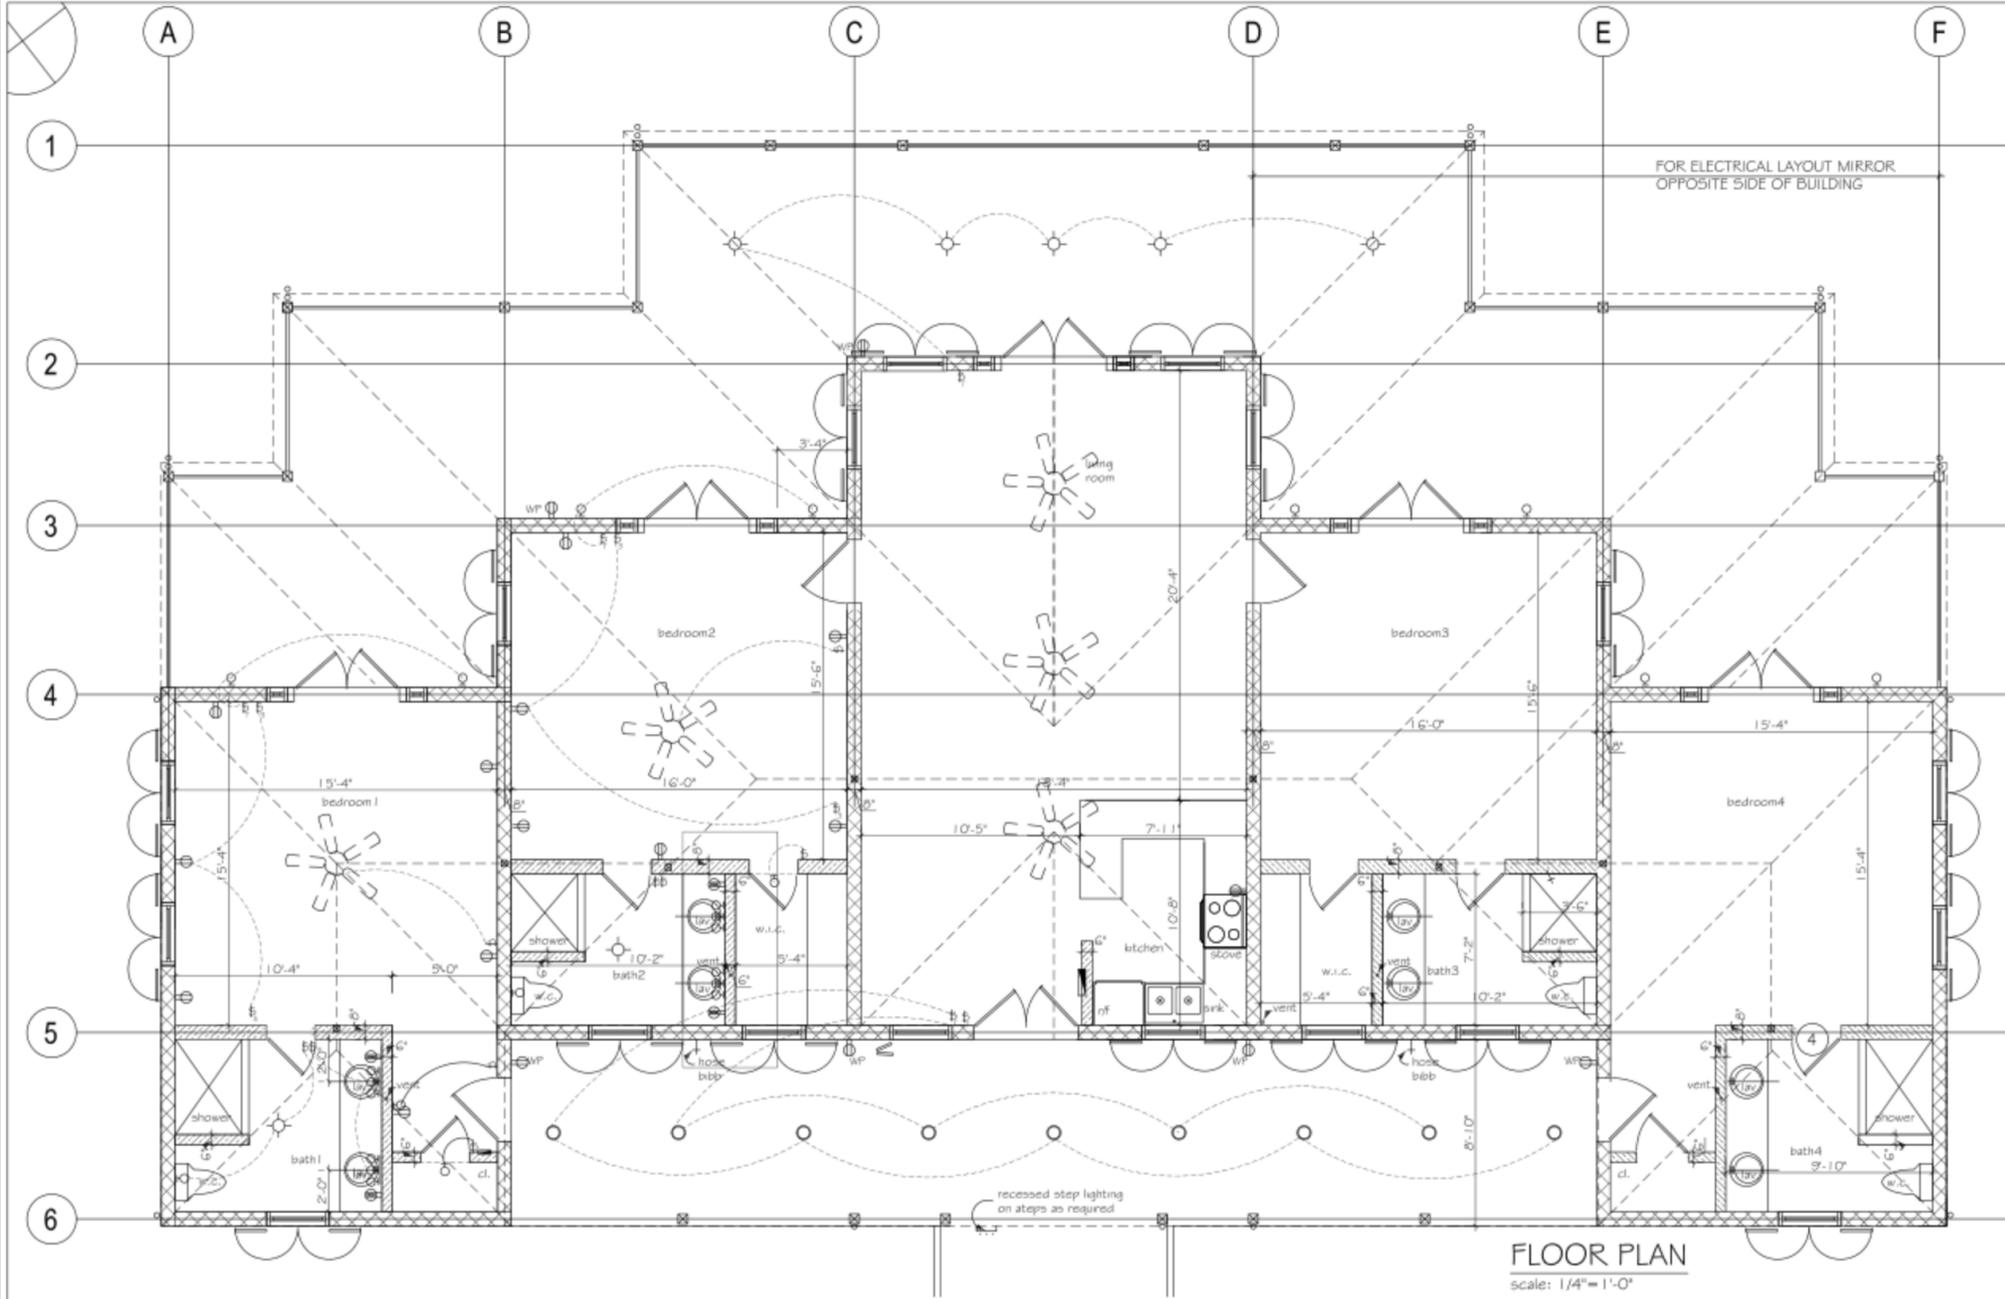

**FLOOR PLAN**  
scale: 1/4" = 1'-0"

ELECTRICAL LEGEND			
WP	WEATHER PROOF OUTLET/GFI	○	WALL SCONCE LIGHT
⊕	GFI OUTLET	⊕	EXTERIOR WALL LIGHT
⊕	DUPLEX OUTLET	⊕	CEILING FAN - pull chain
⊕	TOP RECEPTACLE SWITCHED	⊕	ELECTRICAL SMOKE ALARM
⊕	220/240 VOLT OUTLET	○○○	VANITY STRIP
⊕	SINGLE POLE SWITCH	⊕	4 SPEED CLING. FAN SWITCH
⊕	DIMMER SWITCH	⊕	TIMER SWITCH
⊕	ELECTR. PANEL	▲	PHONE
⊕	RECESS SIDE-WALK LIGHT	○	CEILING HUNG LIGHT
		⊕	3 WAY SWITCH

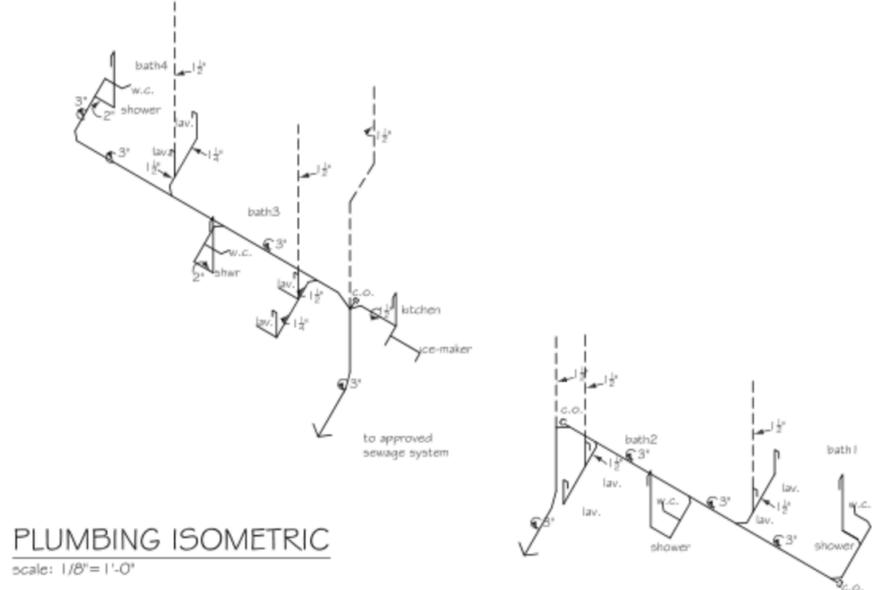

**PLUMBING ISOMETRIC**  
scale: 1/8" = 1'-0"

PROPERTY  
BUILDING ADDITION  
GUEST COTTAGE  
  
LITTLE ST. JAMES Isd.  
RED HOOK QUARTER  
  
ST. THOMAS-U.S. VIRGIN  
ISLANDS

**ELECTRICAL LAYOUT  
PLUMBING ISOMETRIC**

REVISIONS		
No.	DESCRIPTION	DATE

**PAUL  
FERRERAS, PE**  
STRUCTURAL ENGINEER

600122  
St. Thomas, USVI 00801  
Phone: [REDACTED]

NEW YORK LICENSE No 059450  
NEW JERSEY LICENSE GE 32649  
FLORIDA LICENSE No 56408  
VIRGIN ISLANDS LICENSE No 461E

ALL INFORMATION CONTAINED  
HEREIN IS THE PROPERTY OF PAUL  
FERRERAS.  
THE CONCEPTS, IDEAS, DESIGNS  
AND DETAILS AS SHOWN ON THE  
DOCUMENTS WERE CREATED,  
DEVELOPED AND PRESENTED FOR  
USE ON THE SPECIFIC PROJECT  
AND SHALL NOT BE REUSED FOR  
ANY PURPOSE WITHOUT EXPRESS  
WRITTEN CONSENT OF PAUL  
FERRERAS.  
THE OWNER SHALL BE PERMITTED  
TO RETAIN COPIES FOR REFERENCE  
PURPOSE ONLY.

DATE  
Nov. 10th, 2011  
SCALE  
As Noted  
**E-PI**  
10 OF 10