

The Office of  
**THIERRY W. DESPONT**


MECHANICAL ENGINEERS

John L. Altieri  
Consulting Engineer

STRUCTURAL ENGINEERS

Ove Arup & Partners

NO.	DATE	REVISIONS

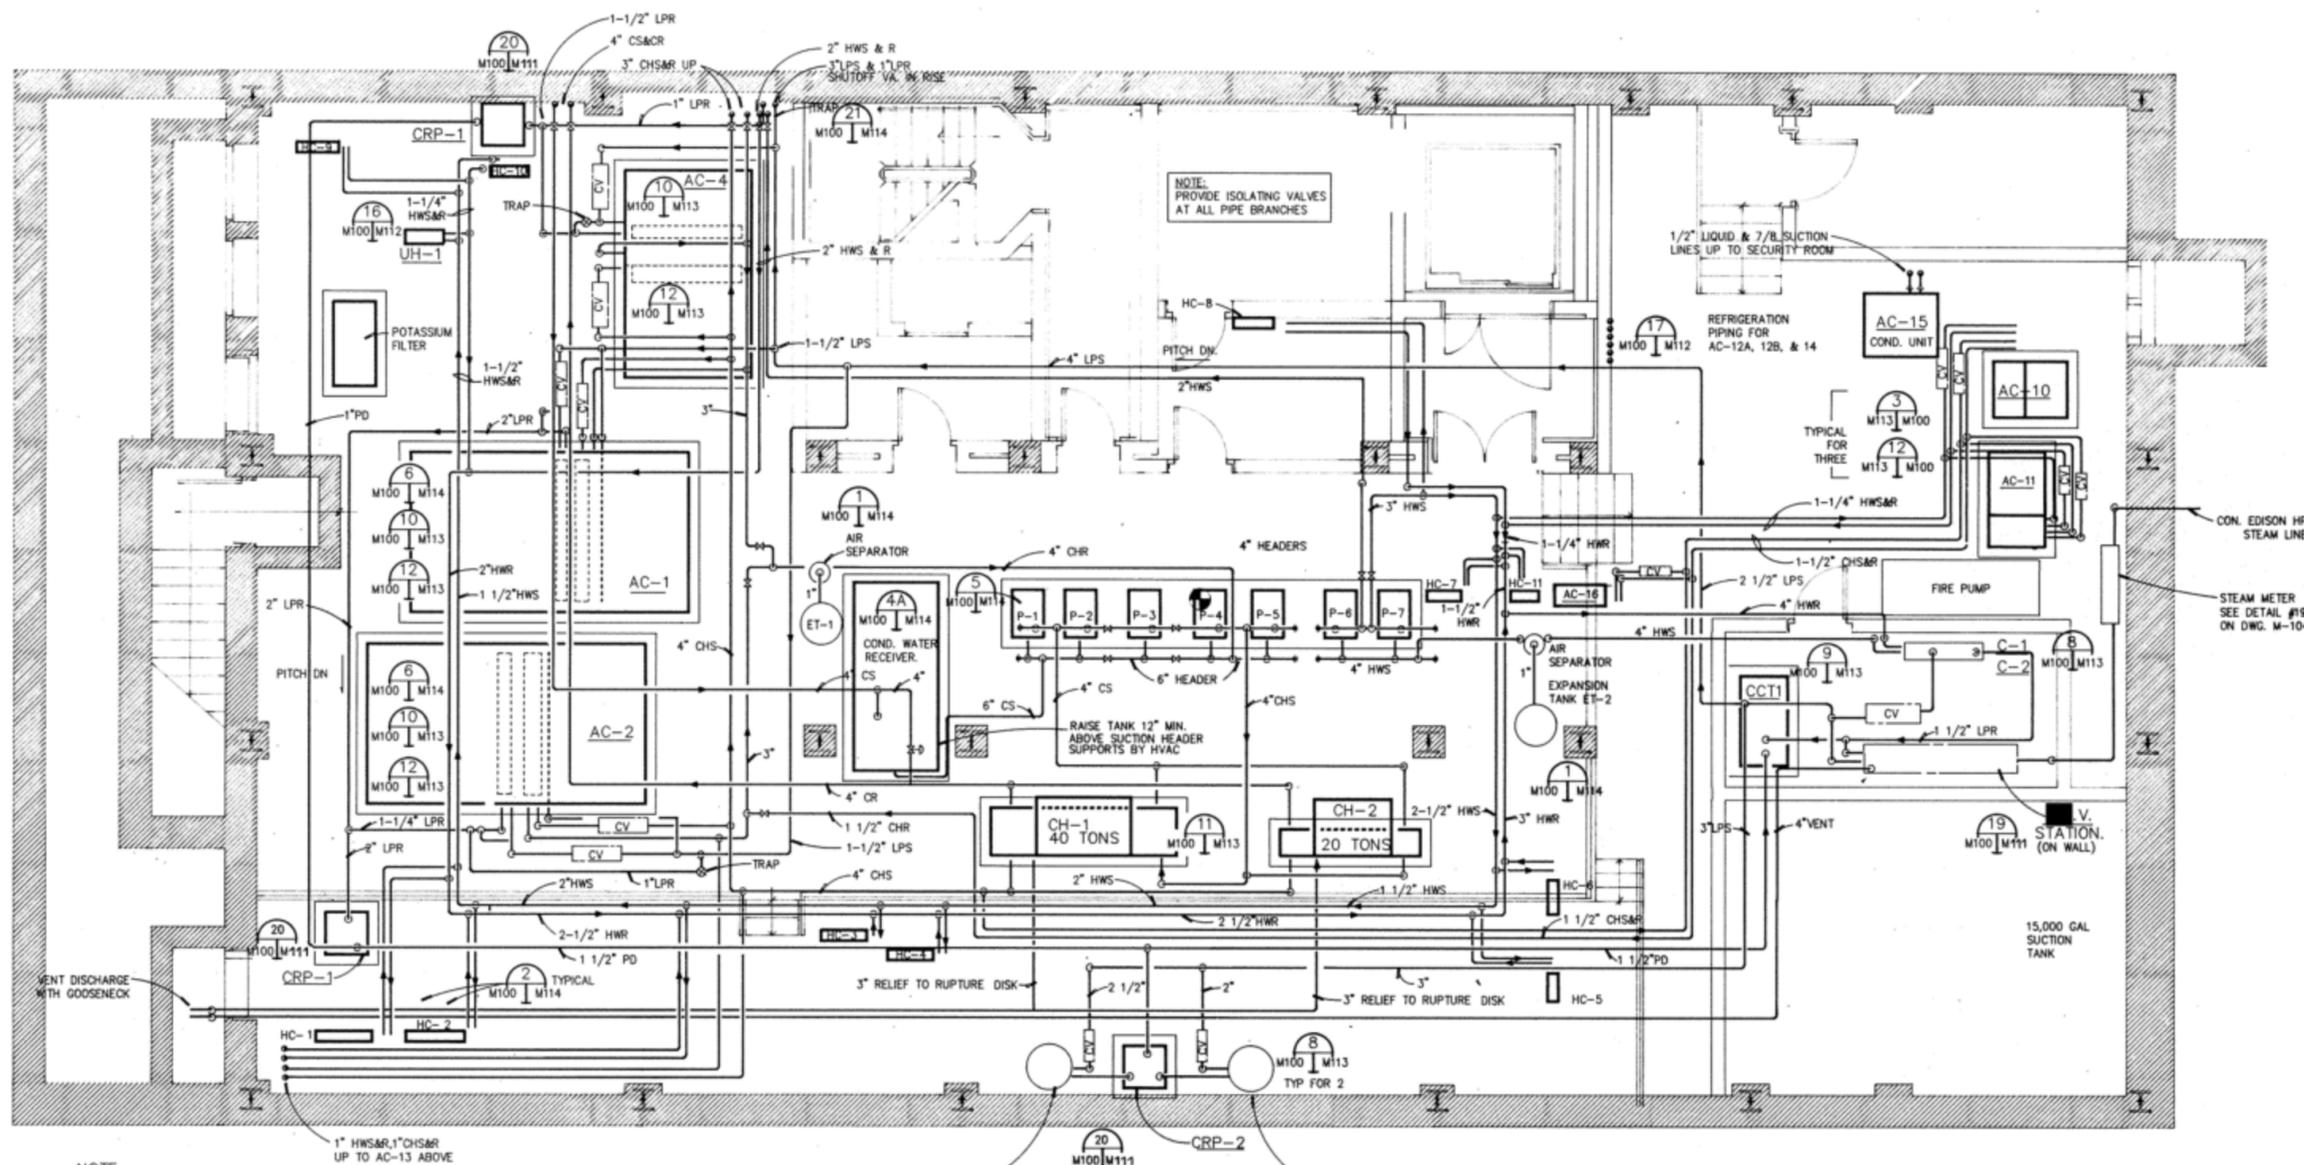

**NOTE:**

- 1) PROVIDE 3/4" CONDENSATE DRAIN CONNECTION FROM THE COILING OF UNIT AC-1, AC-2, AC-4, AC-10, AC-11, AC-9, AC-13 TO NEAREST FLOOR DRAIN
- 2) PROVIDE 4" CLEANABLE DRAIN TRAPS FOR AC-1 & AC-2, 2" FOR AC-10, AC-4, & AC-11, AC-9, AC-13
- 3) RUN CONDENSATE LINES TO THE NEAREST FLOOR DRAIN

DOMESTIC HW HEATER AND STEAM CONTROL VALVE BY PLUMBING

DOMESTIC HW HEATER AND STEAM CONTROL VALVE BY PLUMBING



SUBCELLAR PIPING PLAN

DATE JANUARY 24, 1990

SCALE 1/4" = 1'-0"

DRAWING **M-100**