

The Office of
THIERRY W. DESPONT


MECHANICAL ENGINEERS

John L. Altieri
Consulting Engineers

STRUCTURAL ENGINEERS


Ove Arup & Partners

NO.	DATE	REVISIONS

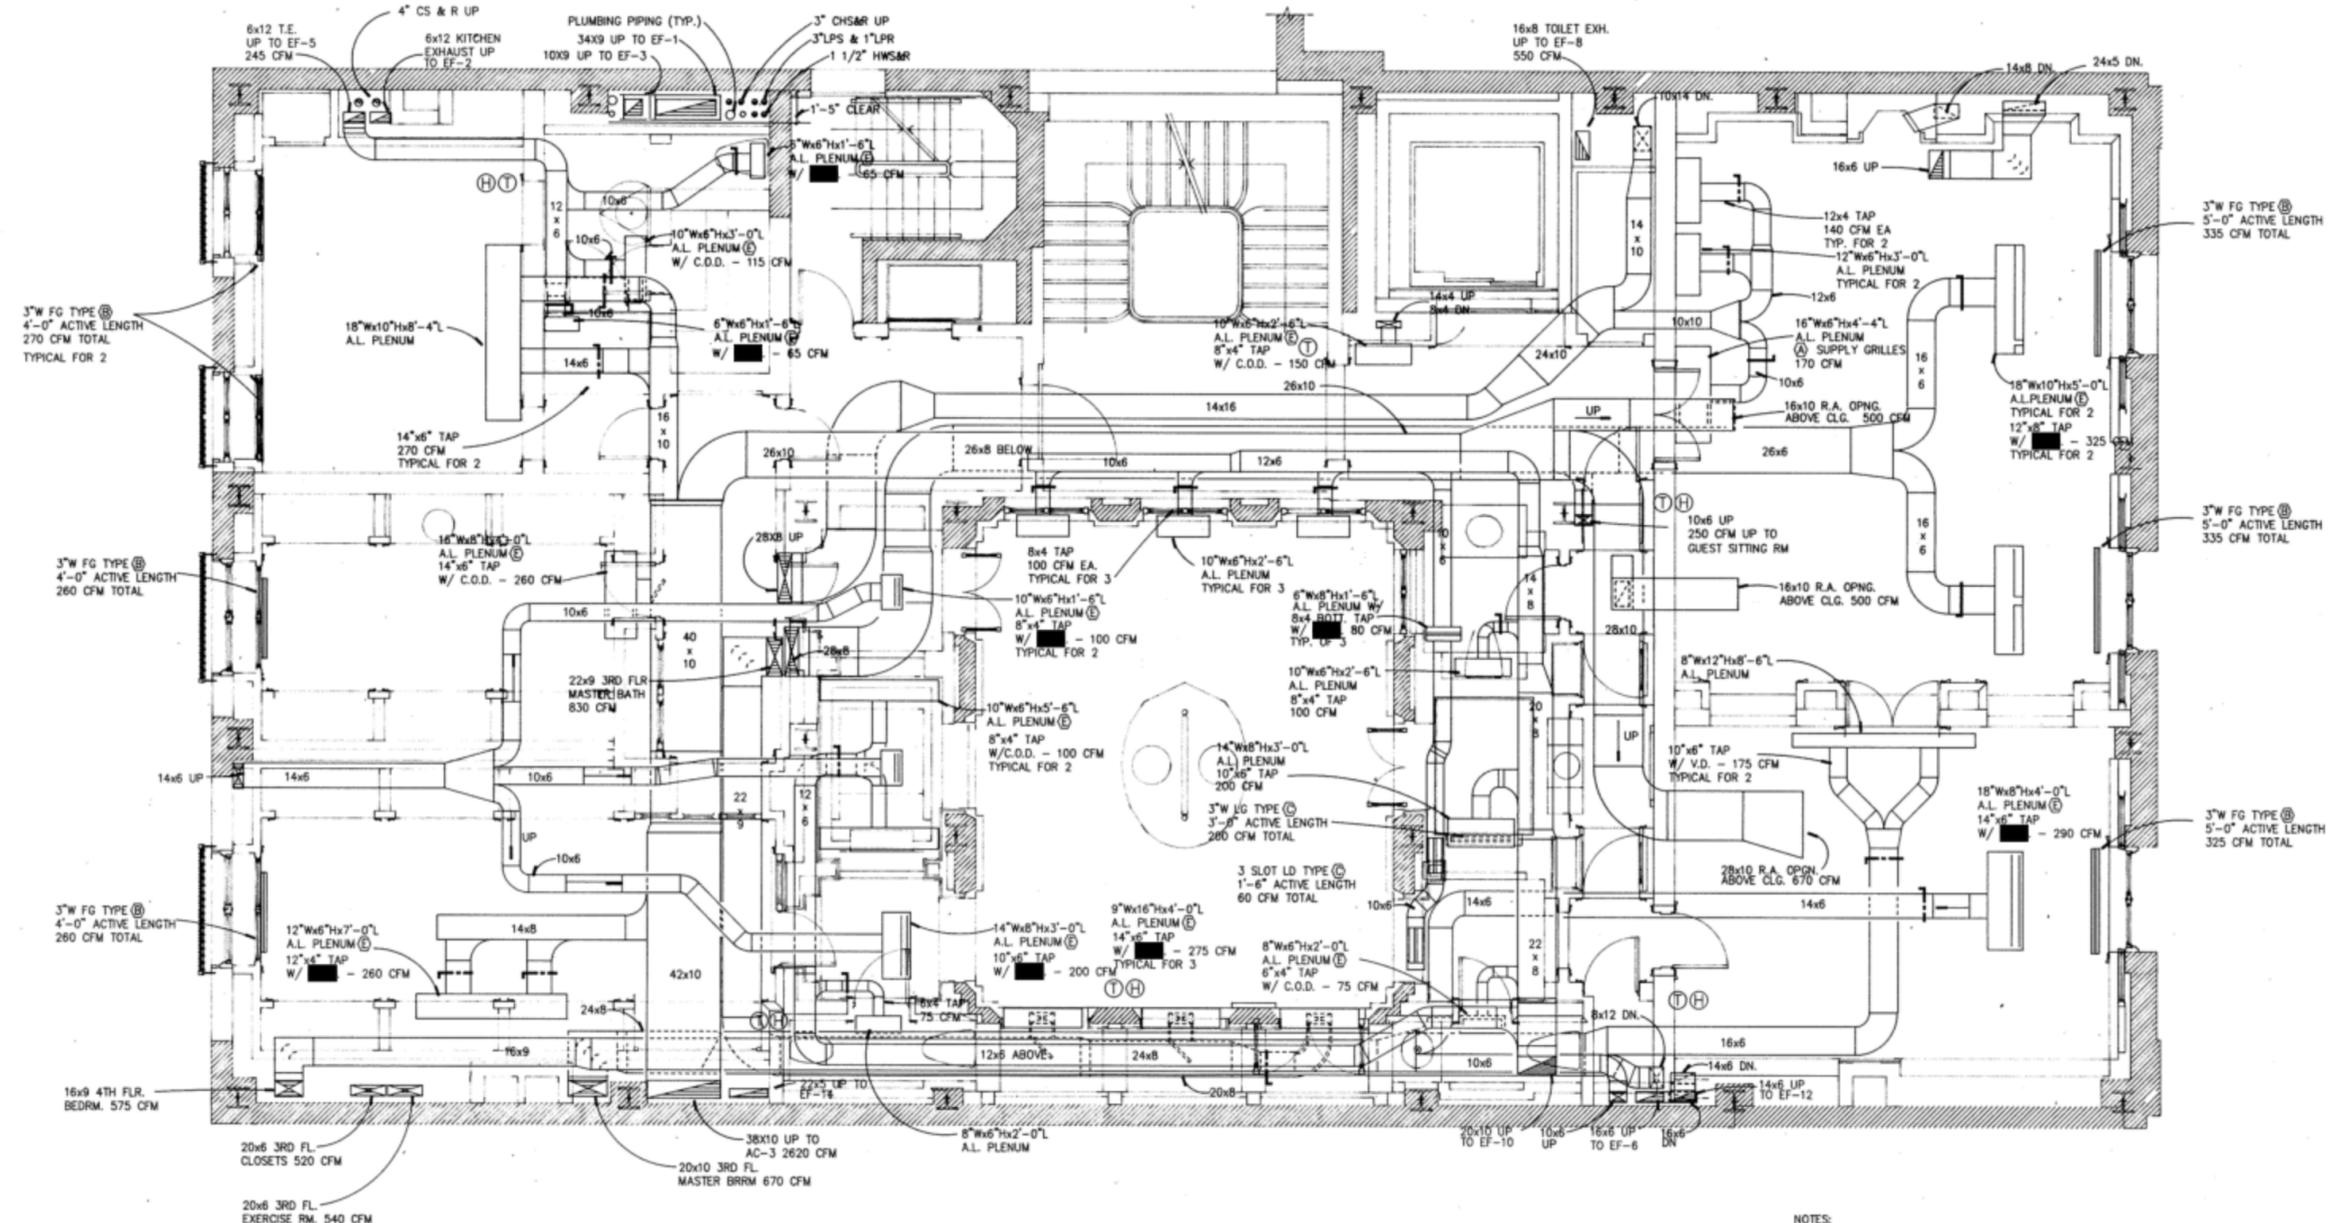

NOTES:

- FOR EXACT SIZES & LOCATIONS OF ALL AIR OUTLETS SEE ARCHITECTURAL DRAWINGS
- FOR ACUSTICAL LINING IN DUCTWORK REQUIREMENTS SEE SPECIFICATION. ALL DIMENSIONS ON LINED DUCT ARE INSIDE DIMENSIONS

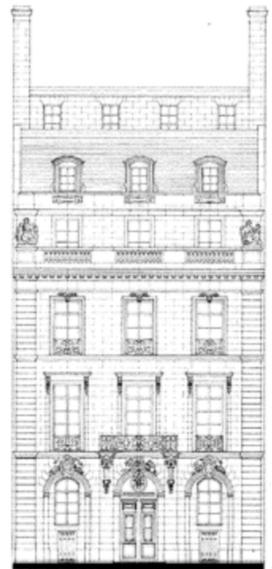

THIRD FLOOR PLAN

DATE JANUARY 24, 1990

SCALE 1/4" = 1'-0"

DRAWING **M-105**

DRAWING NAME: 88203M REVISED: 01/19/90 11:47 PLOTTED: 01/26/90 10:25

© 1989 The Office of Thierry W. Despont Ltd. All Rights Reserved.