

The Office of
THIERRY W. DESPONT


MECHANICAL ENGINEERS

John L. Altieri
Consulting Engineers


STRUCTURAL ENGINEERS

Ove Arup & Partners

NO.	DATE	REVISIONS

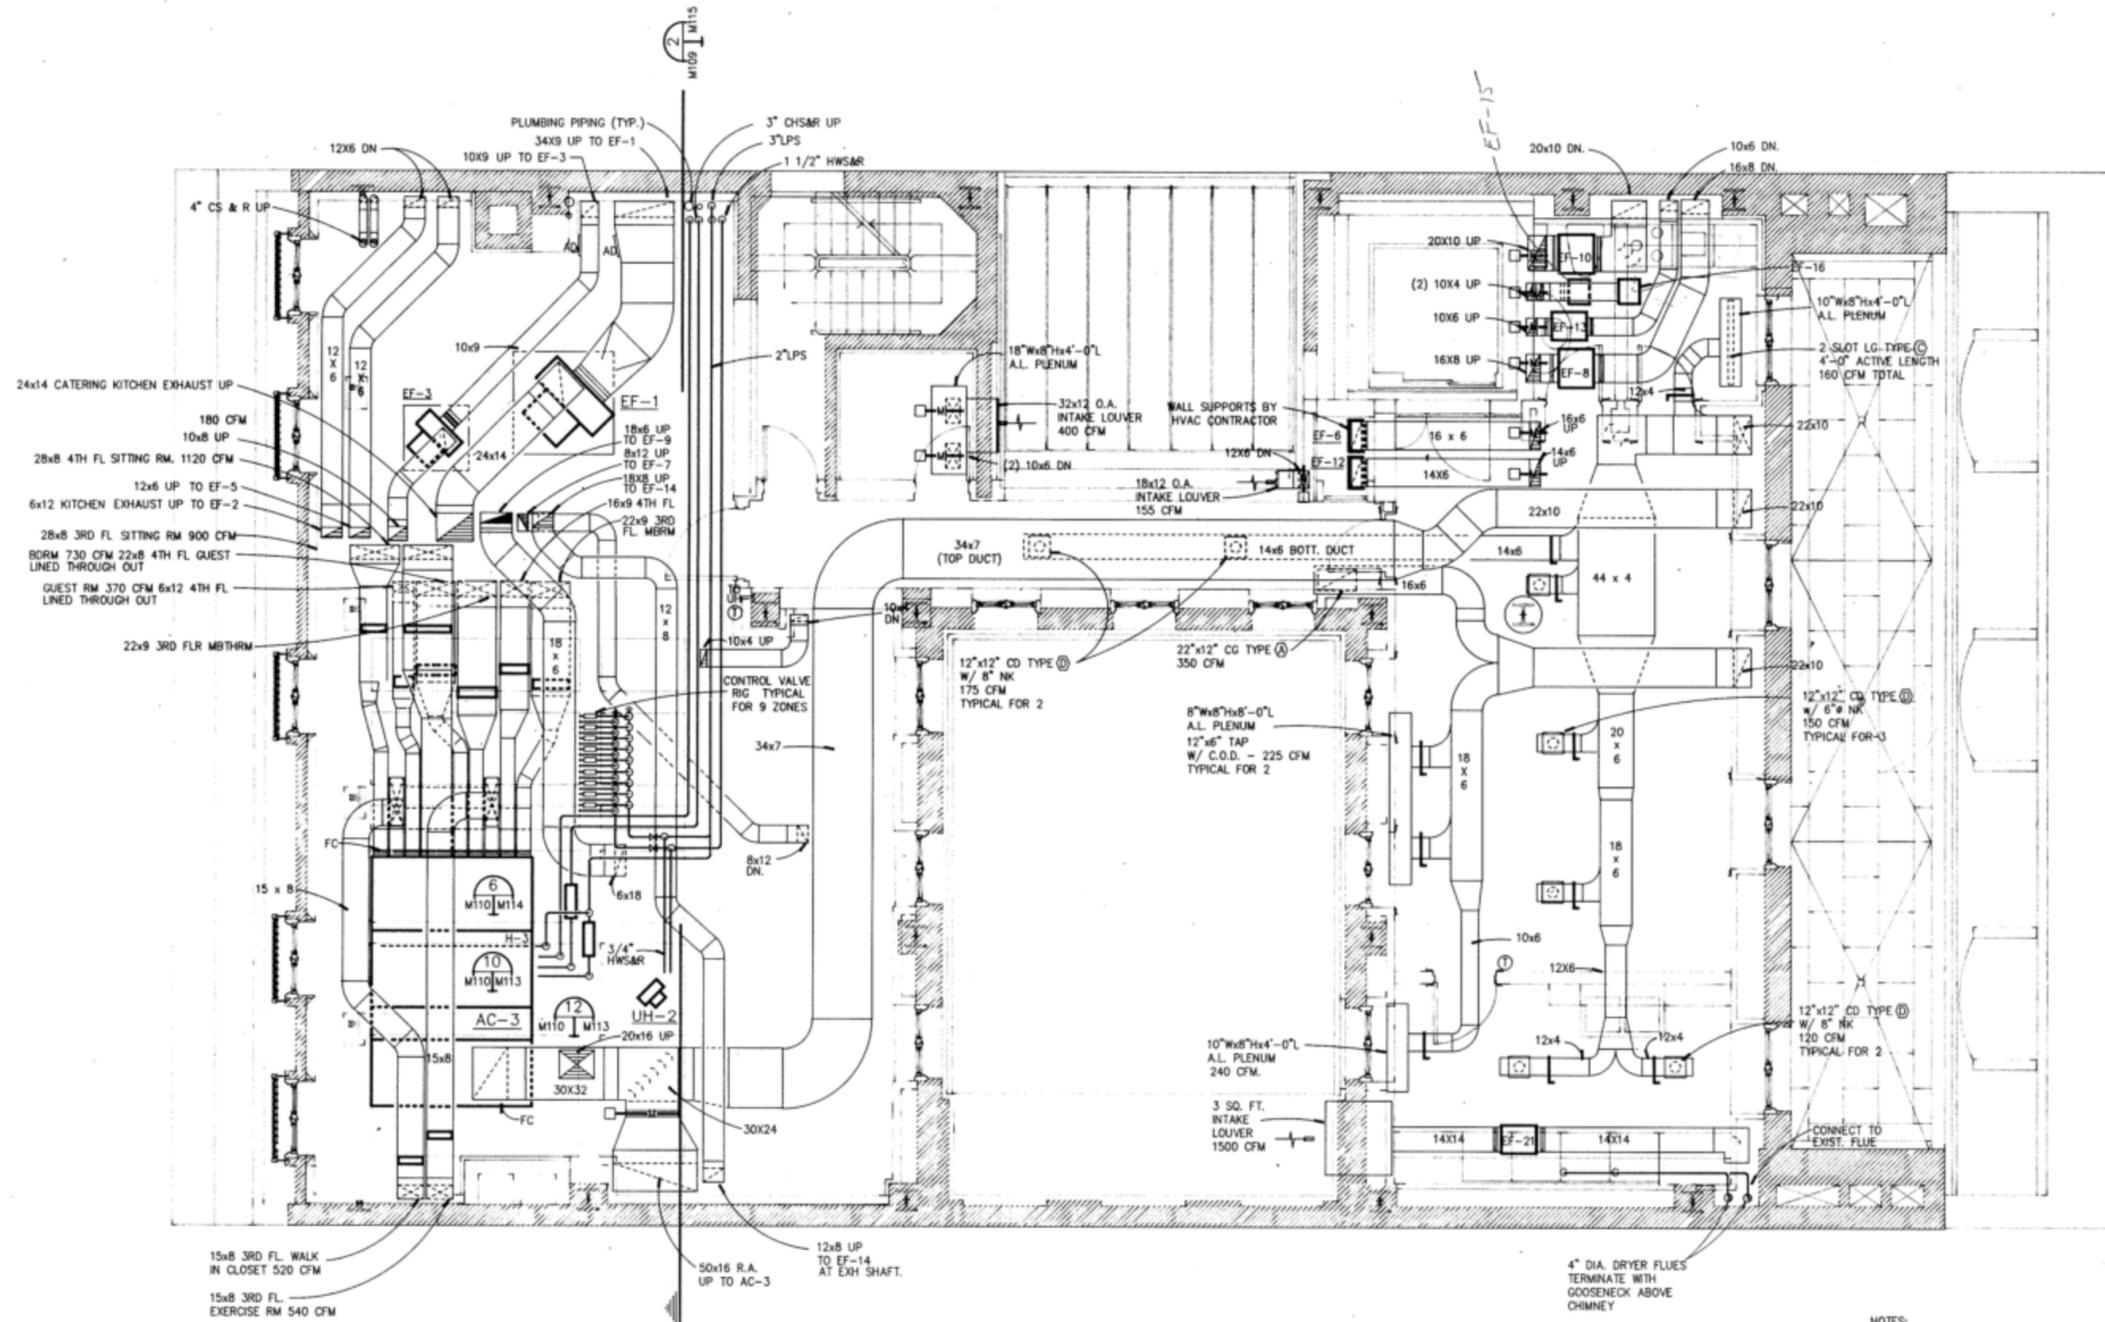

NOTES:
 - FOR EXACT SIZES & LOCATIONS OF ALL AIR OUTLETS SEE ARCHITECTURAL DRAWINGS
 - FOR ACOUSTICAL LINING IN DUCTWORK REQUIREMENTS SEE SPECIFICATION. ALL DIMENSIONS ON LINED DUCT ARE INSIDE DIMENSIONS

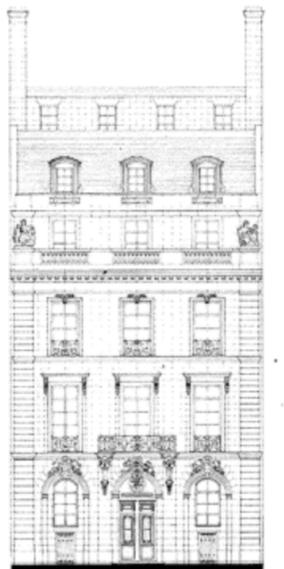

SIXTH FLOOR PLAN
 DATE: JANUARY 24, 1990
 SCALE: 1/4" = 1'-0"
 DRAWING: **M-108**

DRAWING NAME: 88200M REVISION: 01/25/90 13:14 PLOTTED: 01/23/90 08:31

© 1989 The Office of Thierry W. Despont Ltd. All Rights Reserved.